



FIRST FLOOR PLAN +3.00

Scale 1:100

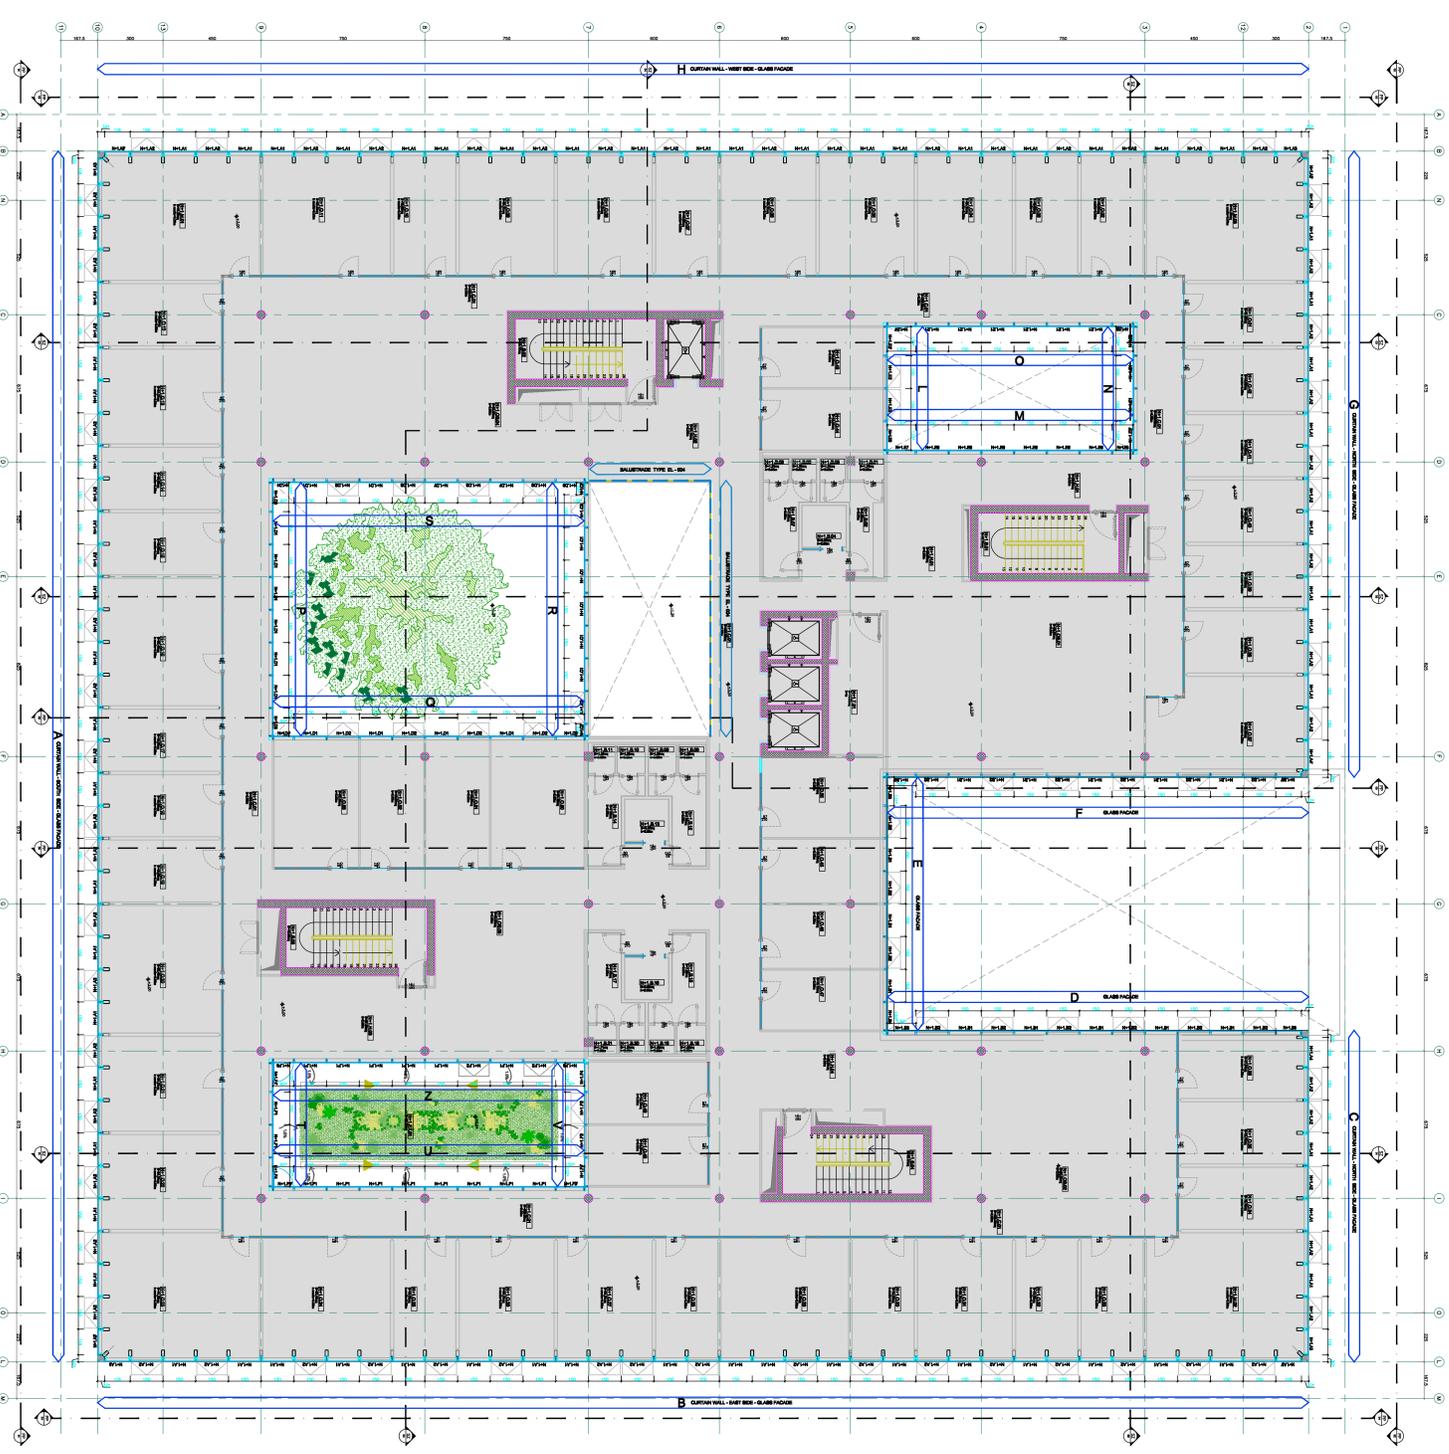


THE CURTAIN WALL TYPES IN THE FIRST FLOOR PLAN +3.00


Scale 1:200

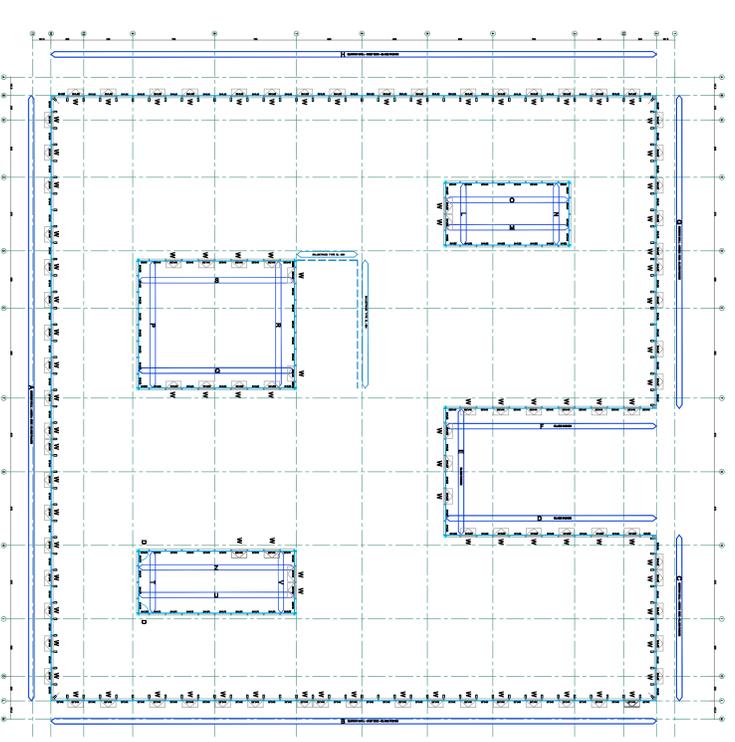

KEY-PLAN FIRST FLOOR +3.00

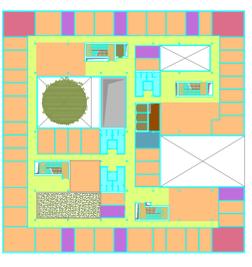


KEY - SECTION



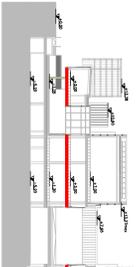


 <p>MINISTARSTVO GRAĐEVINARSTVA I URBANIZACIJE REPUBLIKE SRBIJE</p>		<p>POSREDOVANJE U PROMETU NEKRETNIM PRAVIMA I PROMET POSREDOVANJE U PROMETU NEKRETNIM PRAVIMA I PROMET POSREDOVANJE U PROMETU NEKRETNIM PRAVIMA I PROMET</p>	
<p>RSM POSREDOVANJE U PROMETU NEKRETNIM PRAVIMA I PROMET POSREDOVANJE U PROMETU NEKRETNIM PRAVIMA I PROMET</p>		<p>DFS POSREDOVANJE U PROMETU NEKRETNIM PRAVIMA I PROMET POSREDOVANJE U PROMETU NEKRETNIM PRAVIMA I PROMET</p>	
<p>MC R POSREDOVANJE U PROMETU NEKRETNIM PRAVIMA I PROMET POSREDOVANJE U PROMETU NEKRETNIM PRAVIMA I PROMET</p>		<p>STUDIO SYNTHESIS POSREDOVANJE U PROMETU NEKRETNIM PRAVIMA I PROMET POSREDOVANJE U PROMETU NEKRETNIM PRAVIMA I PROMET</p>	
<p>REGIONAL OBJECT: - objekat: Vilele One Gore ENERGETSKI EFIKASNA ZGRADA Dizajn: "Vilele One Gore" - "Vilele One Gore" Podizanje: One Gore</p>			
<p>MAIN DESIGN</p>		<p>ARCHITECTURAL PRODUCT</p>	
<p>THE CURTAIN WALL FACADES AND BALUSTRADE FIRST FLOOR PLAN +3.00</p>			
<p>DATE: 07.10.2022</p>		<p>SCALE: 1:100</p>	
<p>PROJECT: Ae_07_102</p>		<p>DESIGNER: MC R</p>	

SECOND FLOOR PLAN +7.00
Scale 1:100

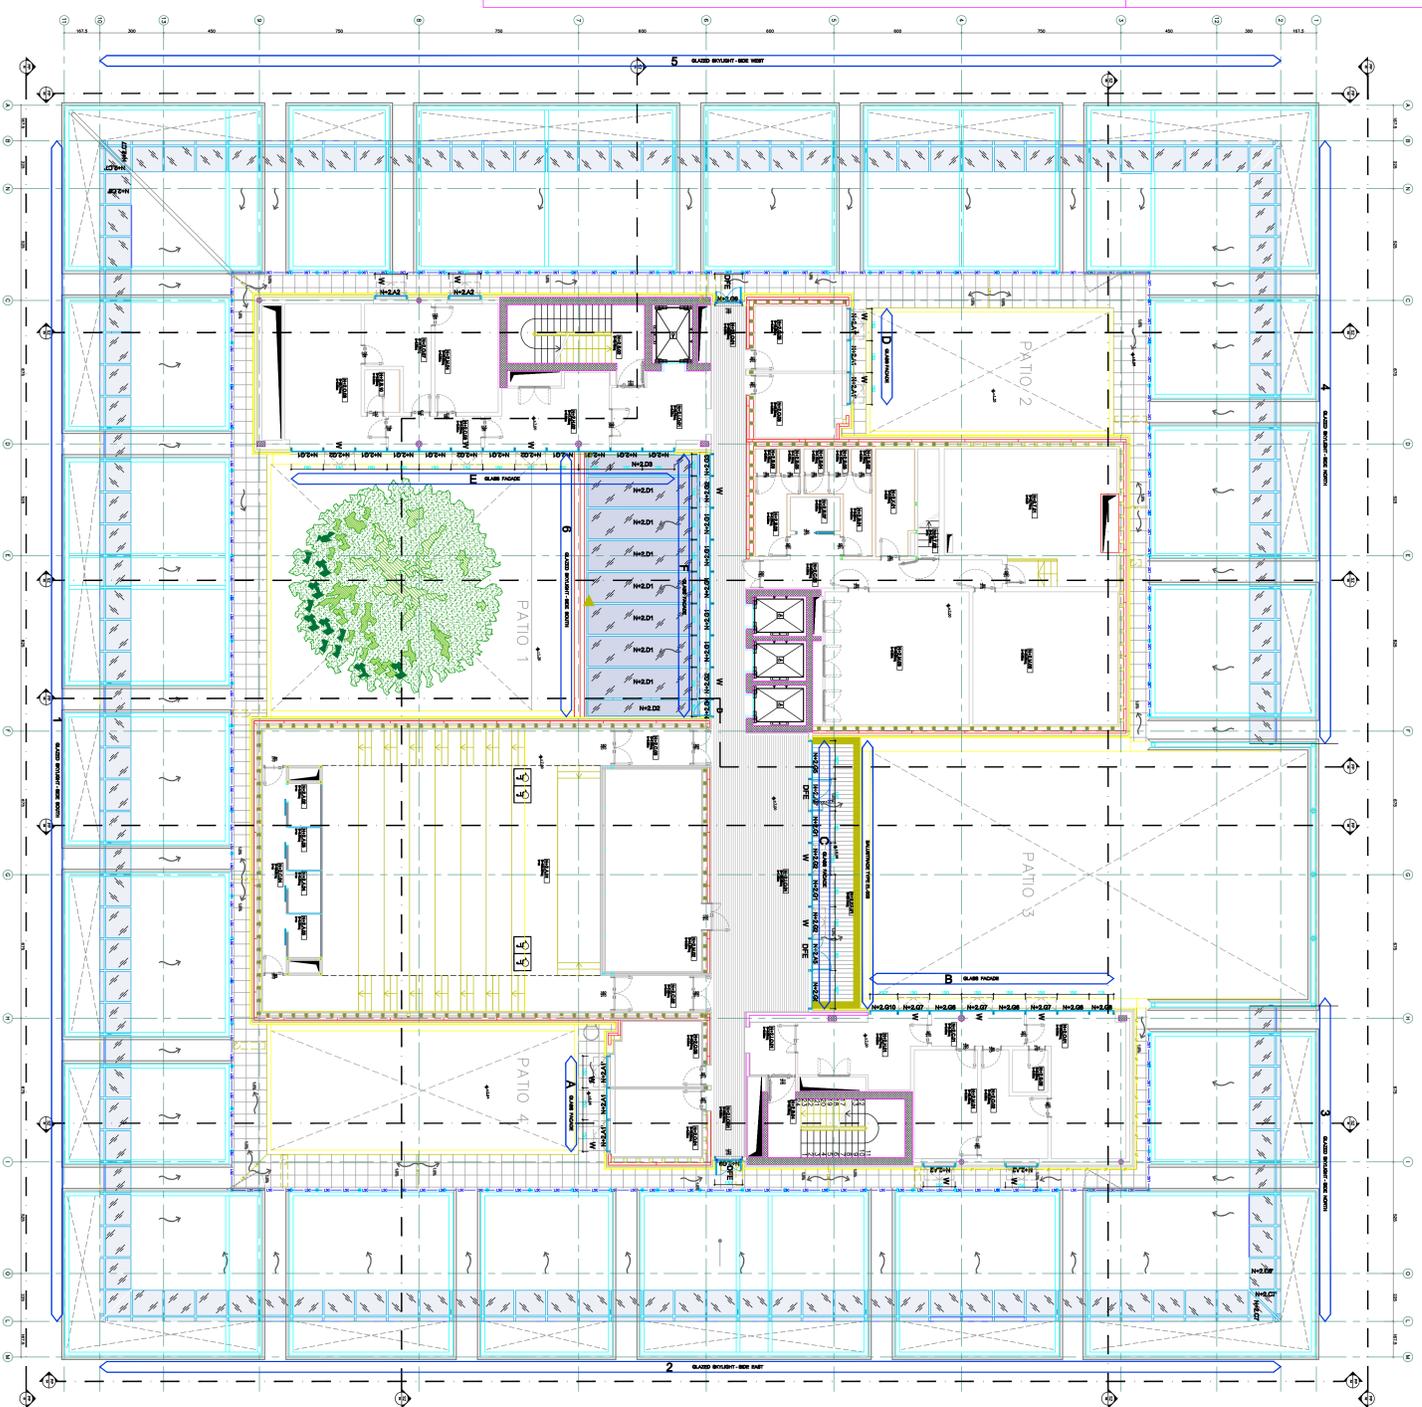

THE CURTAIN WALL IN THE SECOND FLOOR PLAN +7.00
Scale 1:200

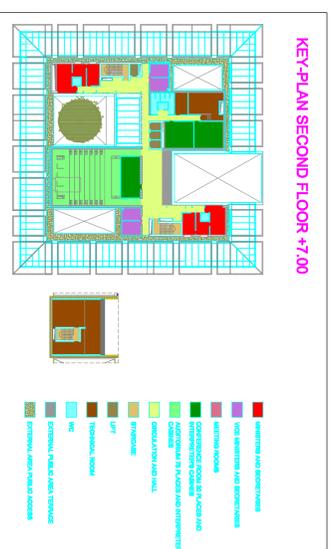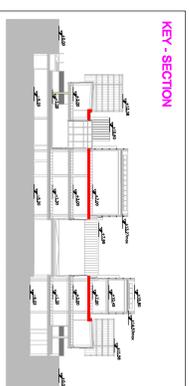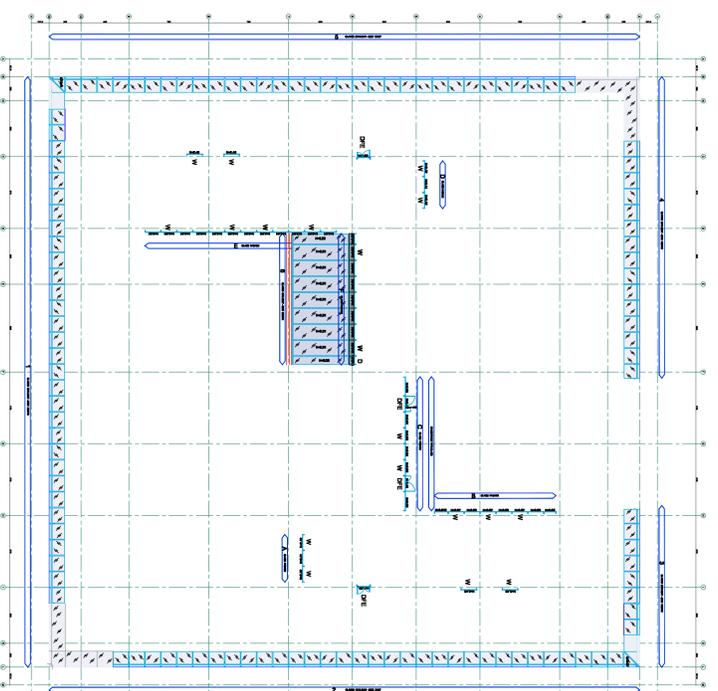

PROJECT OF ENVIRONMENTAL AND SOCIAL IMPACT STUDY AND IMPLEMENTATION OF THE ENVIRONMENTAL MANAGEMENT SYSTEM IN THE REPUBLIC OF ITALY
IZVJEŠĆE ZAVRŠNE STADIJE

MC R
studio SYNTHESIS
architecture & design

DFP
DIZAJN I PROJEKCIJA

NONA BENEQUA
ARCHITETTURA

PROJEKTOVALI: objeekat Vrhovni Odbor Čoveka
Dizajnerski tim: ERVIJKA ŠKOFIĆ, ZORAN ĐURĐEVIĆ, Željko Čičak, Željko Čičak

MAIN DESIGN ARCHITECTURAL PRODUCT

THE CURTAIN WALL PHASES AND BALUSTRADE
SECOND FLOOR PLAN +7.00

Ae 07_103

1	INDEX AND LEGEND MATERIAL
2	EL-001 GROUND FLOOR ELEVATION AND SECTION
3	H-001 GROUND FLOOR DETAIL
4	H-002 GROUND FLOOR DETAIL
5	H-003 GROUND FLOOR DETAIL
6	H-005 GROUND FLOOR DETAIL
7	H-006 GROUND FLOOR DETAIL
8	H-007 GROUND FLOOR DETAIL
9	V-001 GROUND FLOOR DETAIL
10	V-002 GROUND FLOOR DETAIL
11	V-003 GROUND FLOOR DETAIL
12	V-004 GROUND FLOOR DETAIL
13	V-005 GROUND FLOOR DETAIL
14	V-006 GROUND FLOOR DETAIL
15	EL-002 FIRST FLOOR ELEVATION AND SECTION
16	H-004A FIRST FLOOR DETAIL
17	H-004B FIRST FLOOR DETAIL
18	V-007A FIRST FLOOR DETAIL
19	V-007B FIRST FLOOR DETAIL
20	V-008 FIRST FLOOR DETAIL
21	V-009 FIRST FLOOR DETAIL
22	V-010 FIRST FLOOR DETAIL
23	V-011 FIRST FLOOR DETAIL
24	EL-004 INTERNAL GLAZED BALUSTRADE
25	THE CURTAIN WALL FACADES AND BALUSTRADE – GROUND FLOOR PLAN
26	THE CURTAIN WALL FACADES AND BALUSTRADE – FIRST FLOOR PLAN
27	THE CURTAIN WALL FACADES AND BALUSTRADE – SECOND FLOOR PLAN
	EL-006 EXTERNAL ALUMINIUM BALUSTRADE –FIRST FLOOR

LEGEND	
No	MATERIAL
01	DOUBLE GLAZING UNIT OUTER LITE: 10mm. TOUGHENED HST SPACE 20mm. ARGON 90% WE INNER LITE: 55,2 CLEAR FLOAT ACOUSTIC PVB
02	SINGLE GLASS CLEAR FLOAT 10mm th TOUGHENED HST ENAMELLED COLOR RAL...
03	LAMINATED GLASS CLEAR FLOAT 88.4 TOUGHENED HST
10	ALUMINIUM SHEET 15/10 th
11	STAINLESS STEEL SHEET
12	GALVANIZED STEEL SHEET 15/10 th
13	GALVANIZED STEEL BRACKETS
20	ALUMINIUM EXTRUSIONS FOR C.W. PROFILES
30	STAINLESS STEEL SCREW
31	GALVANIZED STEEL SCREW
32	GALVANIZED STEEL BOLTS
33	EXPANSION BOLT
40	SILICONE DC 796 BLACK
41	EPDM EXTRUSION GASKET COLOR BLACK
42	SILICONE EXTRUSION GASKET COLOR BLACK
43	ROCK WOOL
44	1,5 mm thk ADHESIVE RUBBER MEMBRANE
45	RAISED FLOOR FINISH
46	CONCRETE SLAB
47	STEEL COLUMN
48	ALUMINIUM BORDER
49	STONE/CERAMIC FLOOR TILES
50	GYPSUM PLASTERBOARD FINISH
51	HALFEN SYSTEM SUPPORT
52	INTERNAL TEXTILE BLIND
53	ALLUMINIUM SHEET 20/10 th

File : 926_Ae_07_107

Scale :

-

Issue :

Main Project

Detail:

J.N.

926/09

Rev.:


-

The Curtain wall System
Details

Title :

Page:

1

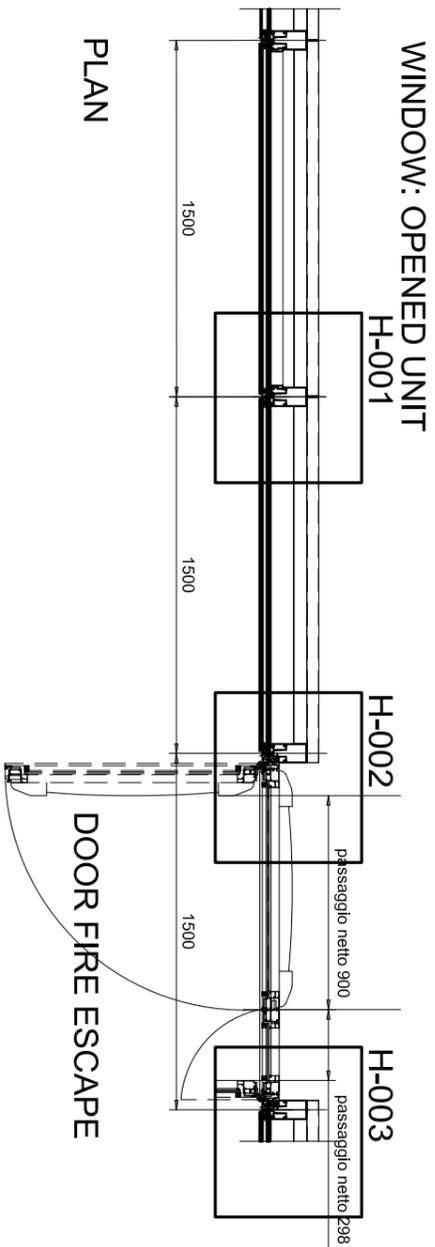

WINDOW: OPENED UNIT


H-001

H-002

H-003


PLAN

DOOR FIRE ESCAPE

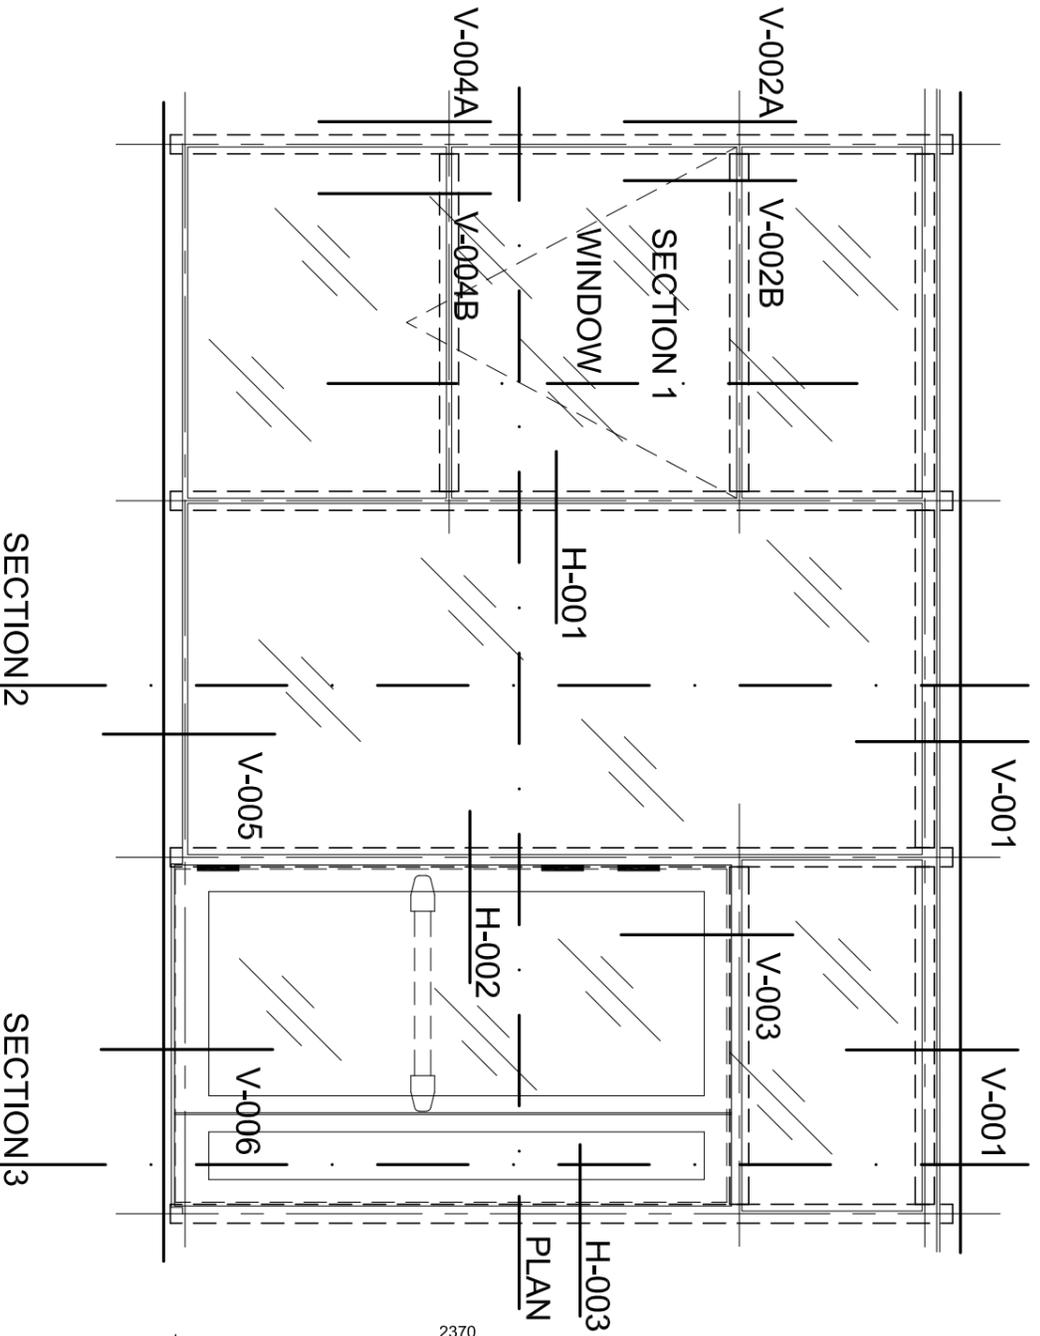


H-003
PLAN

LEGEND	
Nº	MATERIAL
01	DOUBLE GLAZING UNIT OUTER LITE: 10mm, TOUCHED HST SPACE 20mm, ARGON 80% NE ACOUSTIC PVB INNER LITE: 602 CLEAR FLAT 10mm th TOUCHED HST EMANELLED COLOR RAL...
02	SINGLE GLASS CLEAR FLAT 10mm th TOUCHED HST EMANELLED COLOR RAL...
03	LAMINATED GLASS CLEAR FLAT BR-4 TOUCHED HST
10	ALUMINIUM SHEET 15/10 th
11	STAINLESS STEEL SHEET
12	GALVANIZED STEEL SHEET 15/10 th
13	GALVANIZED STEEL BRACKETS
20	ALUMINIUM EXTRUSIONS FOR C.W. PROFILES
30	STAINLESS STEEL SCREW
31	GALVANIZED STEEL SCREW
32	GALVANIZED STEEL BOLTS
33	EXPANSION BOLT
40	SILICONE DC 798 BLACK
41	EPDM EXTRUSION GASKET COLOR BLACK
42	SILICONE EXTRUSION GASKET COLOR BLACK
43	ROCK WOOL
44	1,5 mm thk ADHESIVE RUBBER MEMBRANE
45	RAISED FLOOR FINISH
46	CONCRETE SLAB
47	STEEL COLUMN
48	ALUMINIUM BORDER
49	STONE/CERAMIC FLOOR TILES
50	GYP-SUM PLASTERBOARD FINISH
51	HALTER SYSTEM SUPPORT
52	INTERNAL TEXTILE BLIND
53	ALUMINIUM SHEET 20/10 th

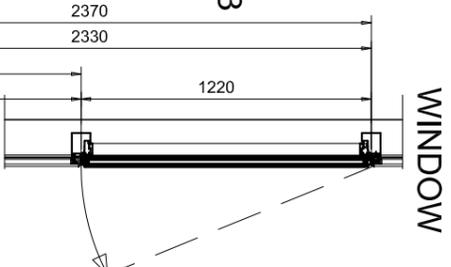

WINDOW

SECTION 1

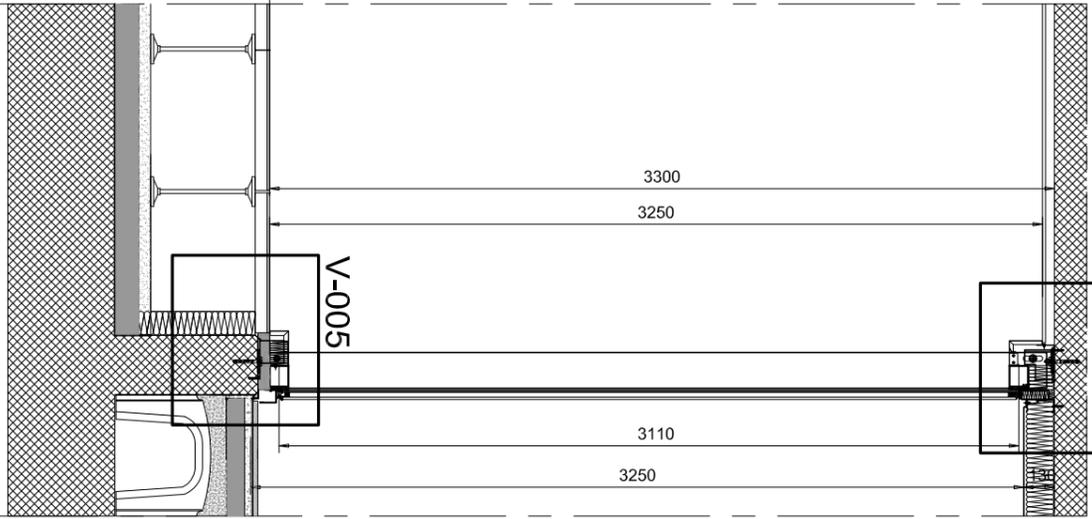


SECTION 2




SECTION 3

File : 926_Ae_07_107		j.n.
Issue :	Scale :	926/09
Main Project	1:30	
Detail:	EL-001	Rev.:
		-

Title : **The Curtain wall Glazing Facade - Ground floor**
Elevation and section

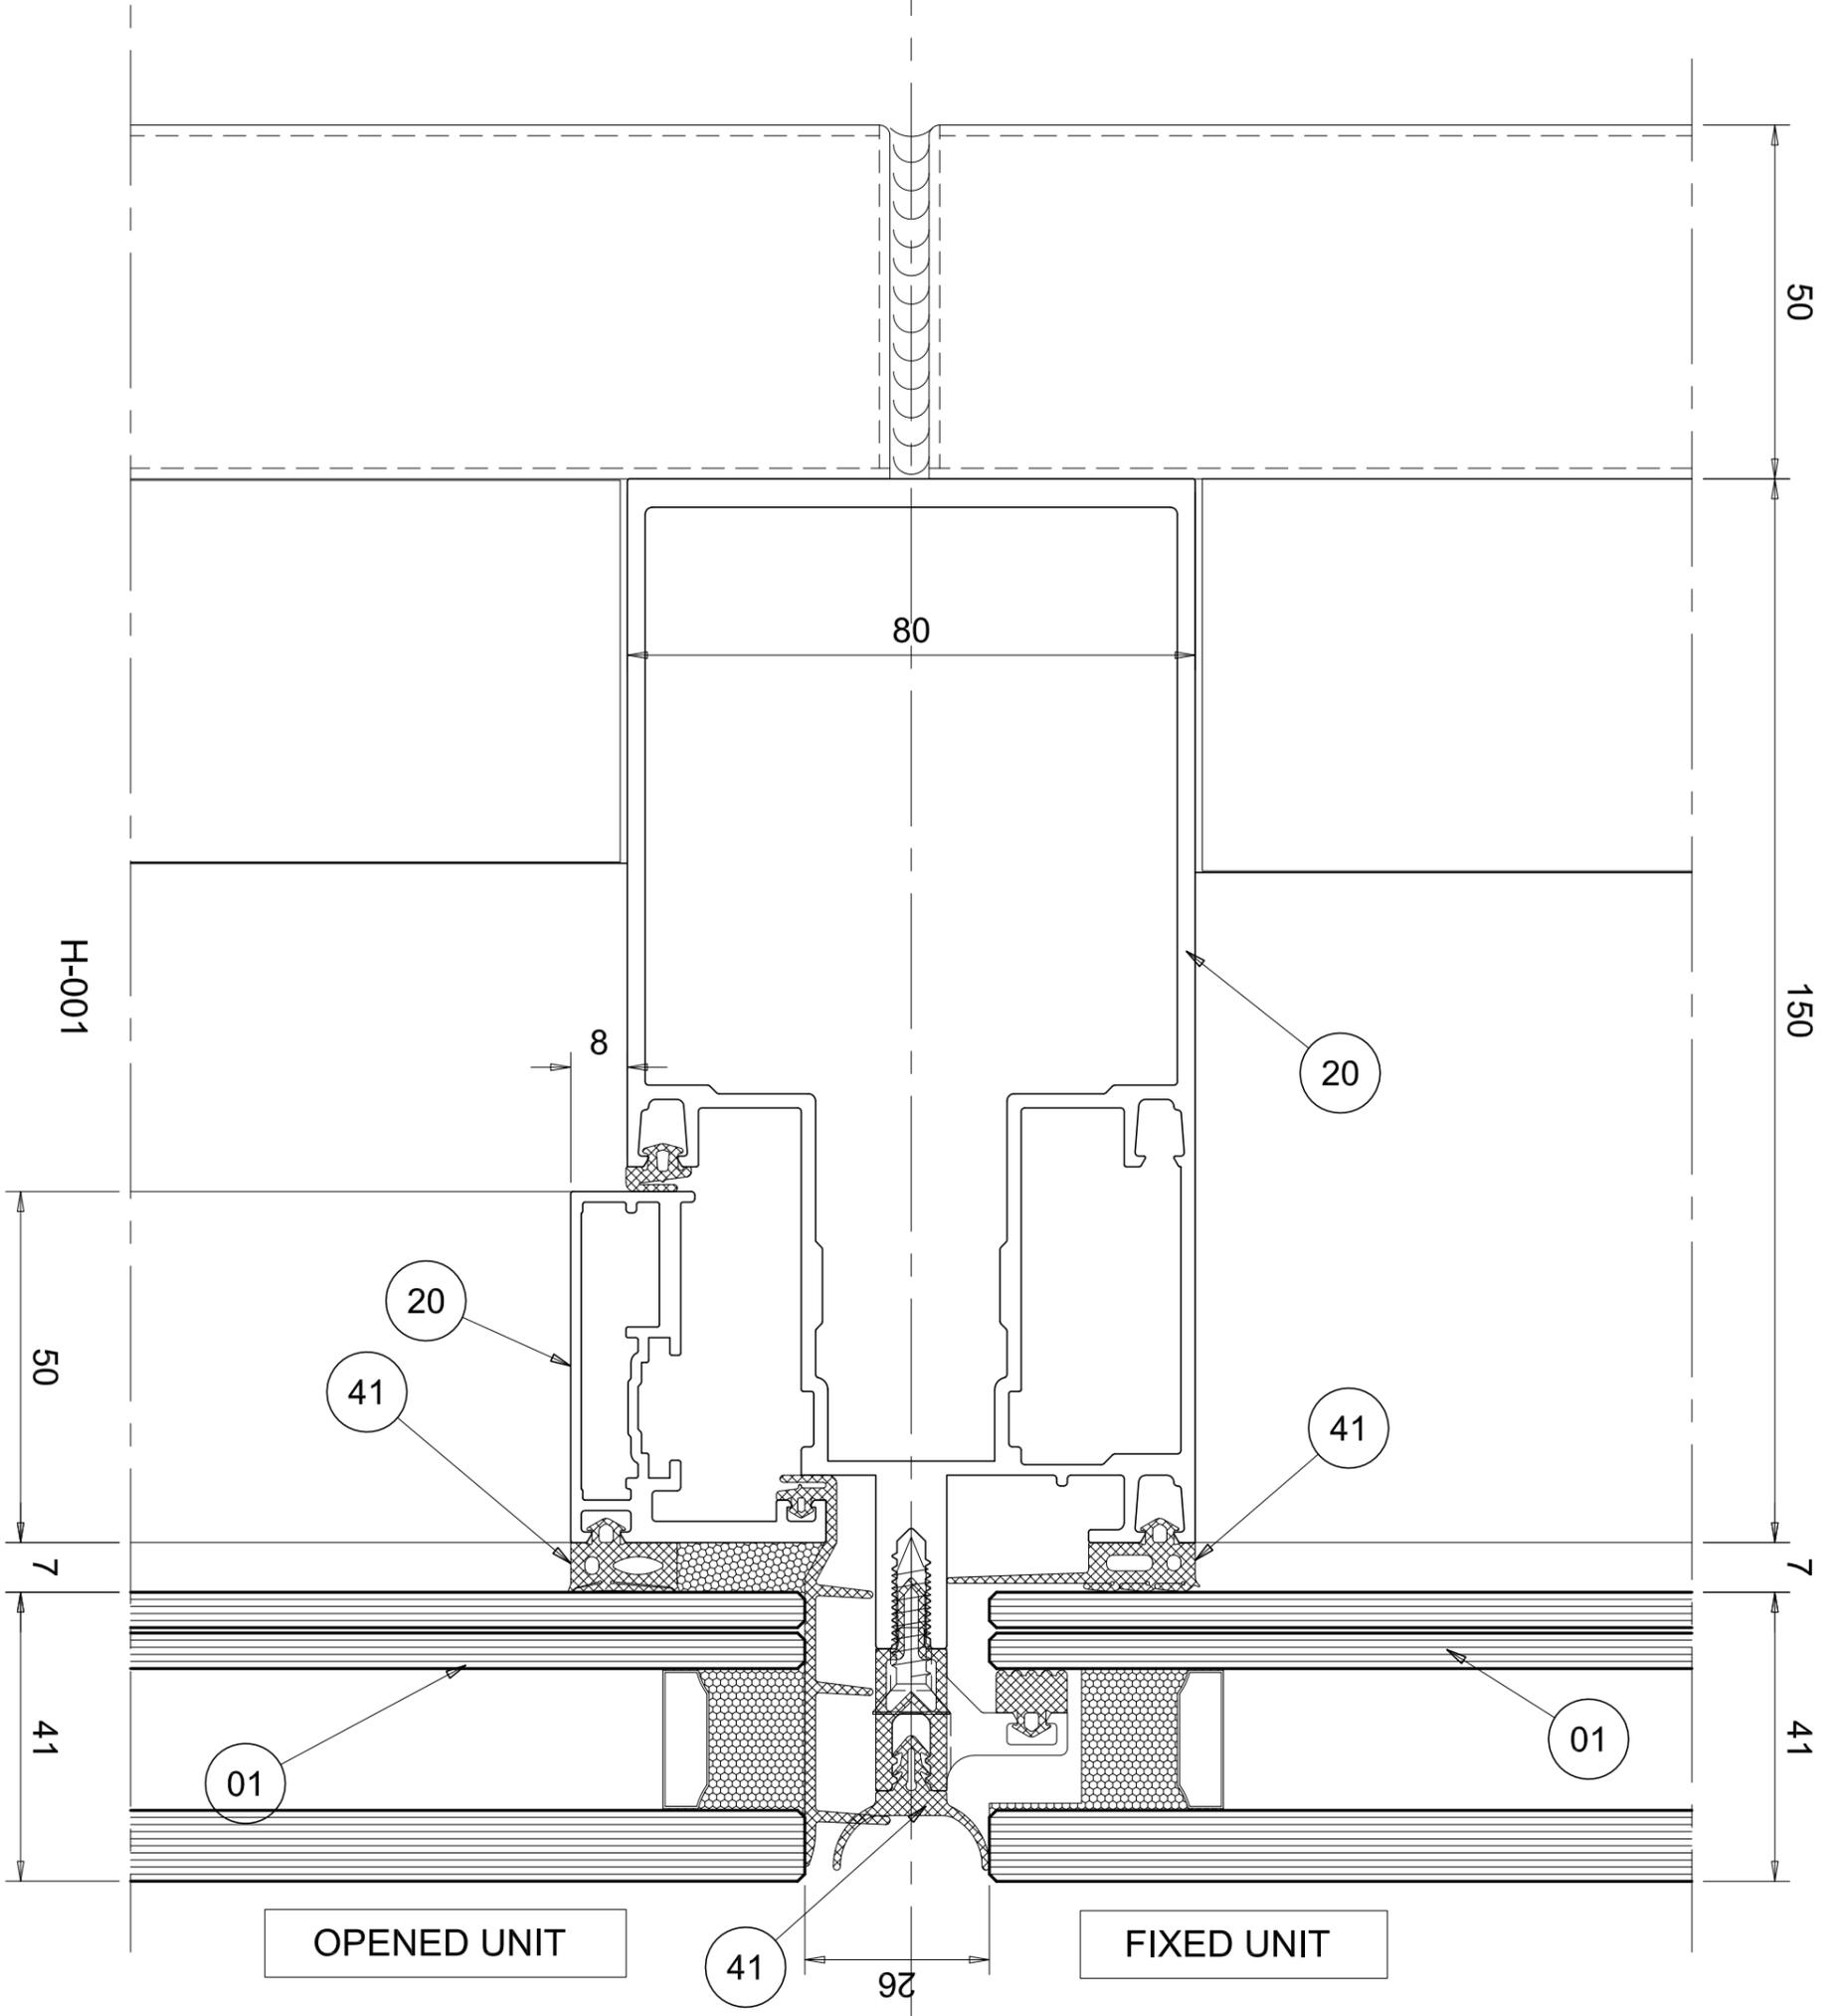


LEGEND	
No	MATERIAL
01	DOUBLE GLAZING UNIT OUTER LITE: 10mm, TOUGHENED HST INNER LITE: 5&2 CLEAR FLOAT ACOUSTIC PVB INTER LITE: 5&2 CLEAR FLOAT ACOUSTIC PVB
02	SINGLE GLASS CLEAR FLOAT 10mm th TOUGHENED HST EMBEDDED COLOR BAL...
03	LAMINATED GLASS CLEAR FLOAT BR-4 TOUGHENED HST
10	ALUMINIUM SHEET 15/10 th
11	STAINLESS STEEL SHEET
12	GALVANIZED STEEL SHEET 15/10 th
13	GALVANIZED STEEL BRACKETS
20	ALUMINIUM EXTRUSIONS FOR C.W. PROFILES
30	STAINLESS STEEL SCREW
31	GALVANIZED STEEL SCREW
32	GALVANIZED STEEL BOLTS
33	EXPANSION BOLT
40	SILICONE DC 796 BLACK
41	EPDM EXTRUSION GASKET COLOR BLACK
42	SILICONE EXTRUSION GASKET COLOR BLACK
43	ROCK WOOL
44	1,5 mm thk ADHESIVE RUBBER MEMBRANE
45	RAISED FLOOR FINISH
46	CONCRETE SLAB
47	STEEL COLUMN
48	ALUMINIUM BORDER
49	STONE/CERAMIC FLOOR TILES
50	GYPSUM PLASTERBOARD FINISH
51	HALFEN SYSTEM SUPPORT
52	INTERNAL TEXTILE BLIND
53	ALUMINIUM SHEET 20/10 th

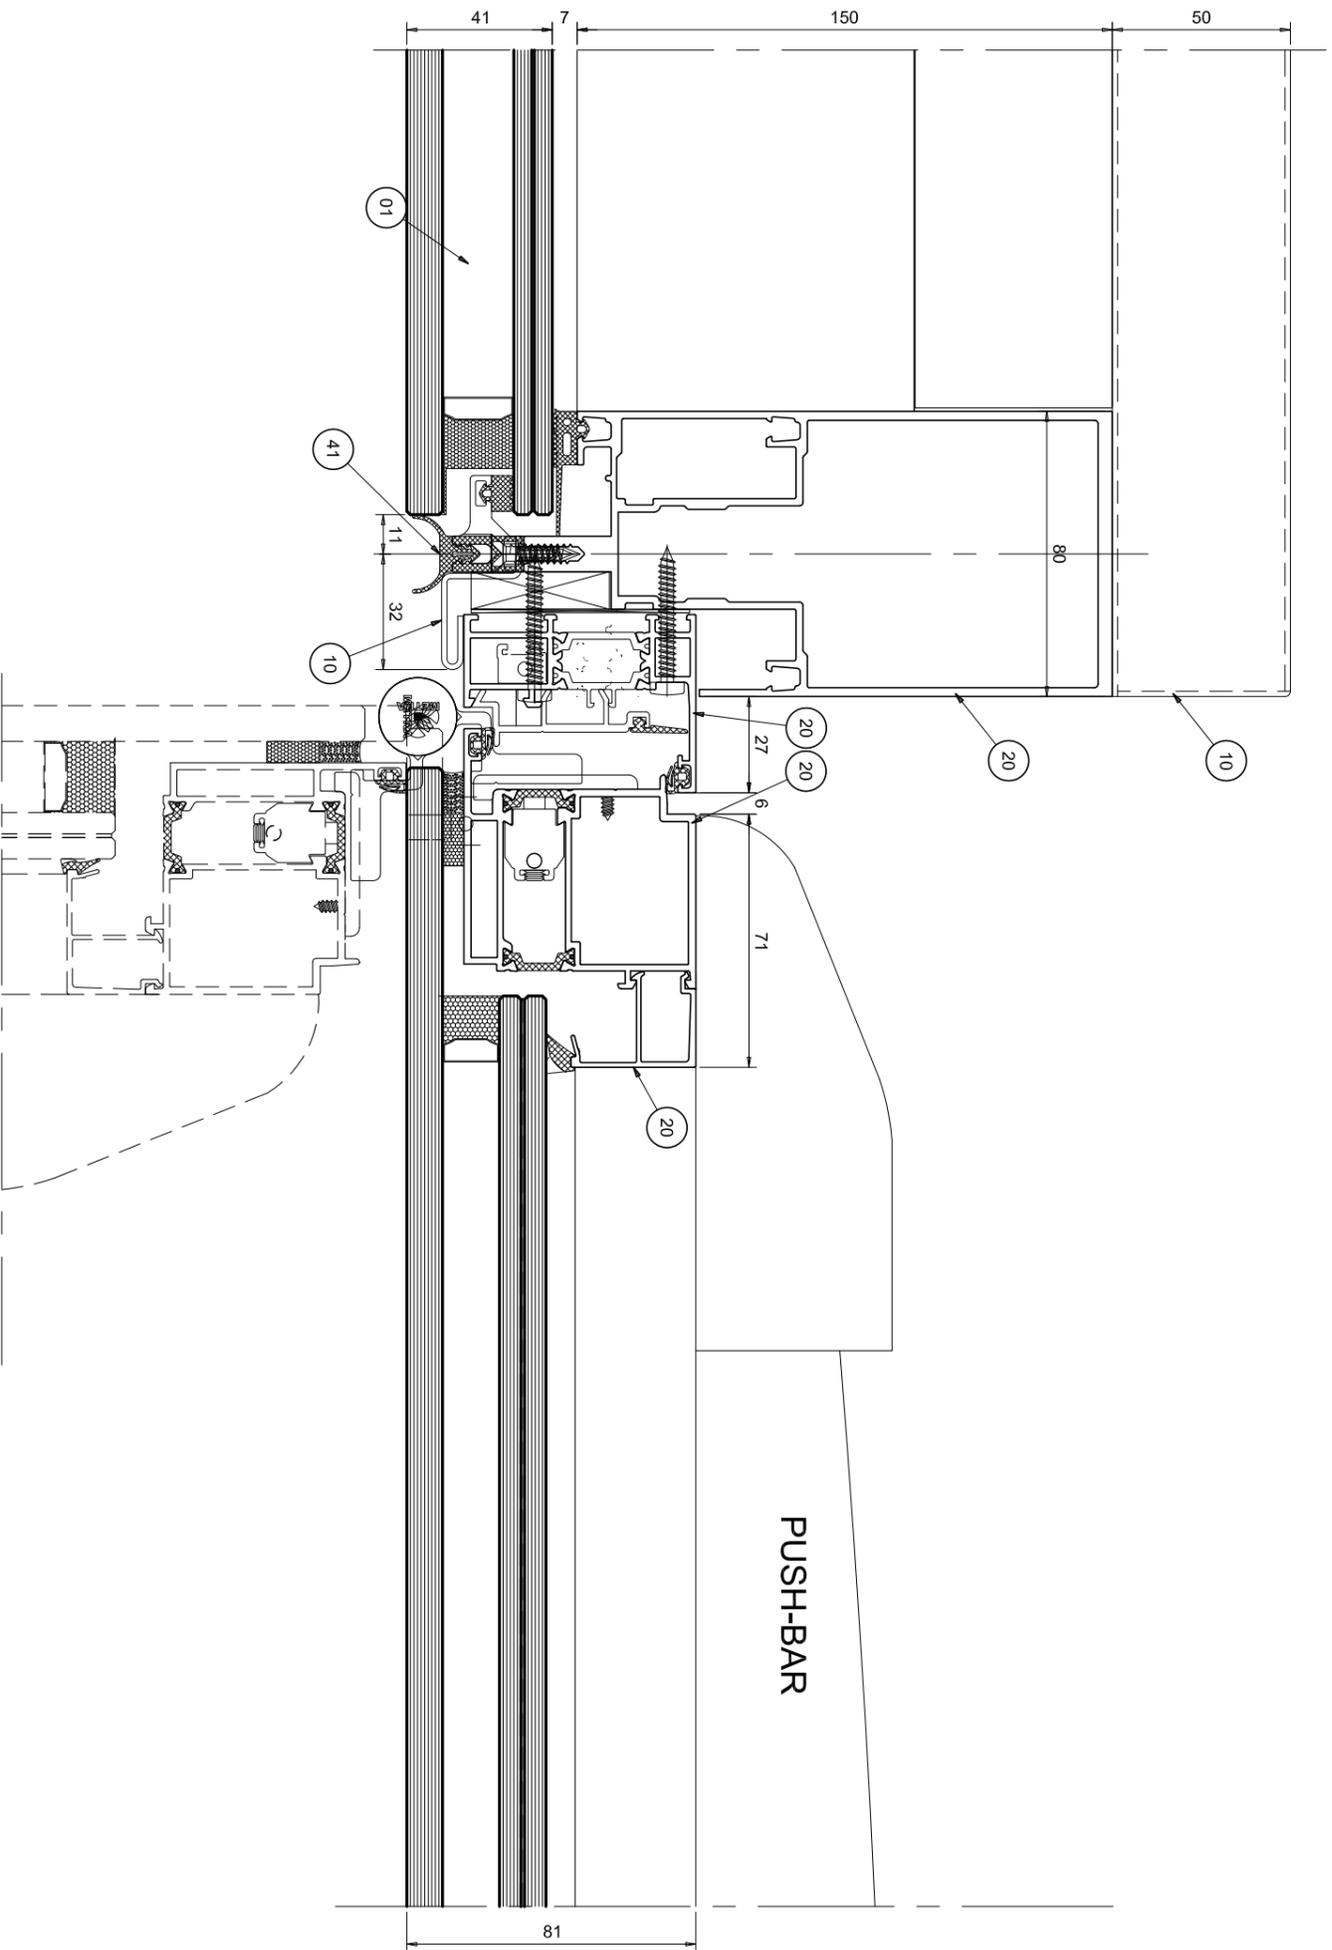

LEGEND	
No	MATERIAL
01	DOUBLE GLAZING UNIT OUTER LITE: 10mm, TOUGHENED HST INNER LITE: 5&2 CLEAR FLOAT ACOUSTIC PVB INTER LITE: 5&2 CLEAR FLOAT ACOUSTIC PVB TOUGHENED HST
02	SINGLE GLASS CLEAR FLOAT 10mm th TOUGHENED HST DRENILED COLOR BAL...
03	LAMINATED GLASS CLEAR FLOAT BR-4 TOUGHENED HST
10	ALUMINIUM SHEET 1&1/10 th
11	STAINLESS STEEL SHEET
12	GALVANIZED STEEL SHEET 1&1/10 th
13	GALVANIZED STEEL BRACKETS
20	ALUMINIUM EXTRUSIONS FOR C.W. PROFILES
30	STAINLESS STEEL SCREW
31	GALVANIZED STEEL SCREW
32	GALVANIZED STEEL BOLTS
33	EXPANSION BOLT
40	SILICONE DC 79& BLACK
41	EPDM EXTRUSION GASKET COLOR BLACK
42	SILICONE EXTRUSION GASKET COLOR BLACK
43	ROCK WOOL
44	1,5 mm thk ADHESIVE RUBBER MEMBRANE
45	RAISED FLOOR FINISH
46	CONCRETE SLAB
47	STEEL COLUMN
48	ALUMINIUM BORDER
49	STONE/CERAMIC FLOOR TILES
50	GYPSUM PLASTERBOARD FINISH
51	HALFEN SYSTEM SUPPORT
52	INTERNAL TEXTILE BLIND
53	ALUMINIUM SHEET 20/10 th

File : 926_Ae_07_107		j.n.
Issue :	Scale :	926/09
Main Project	1:2	Rev.:
Detail:	H-002	-

Title : **The Curtain wall Glazing Facade - Ground floor**
Section detail

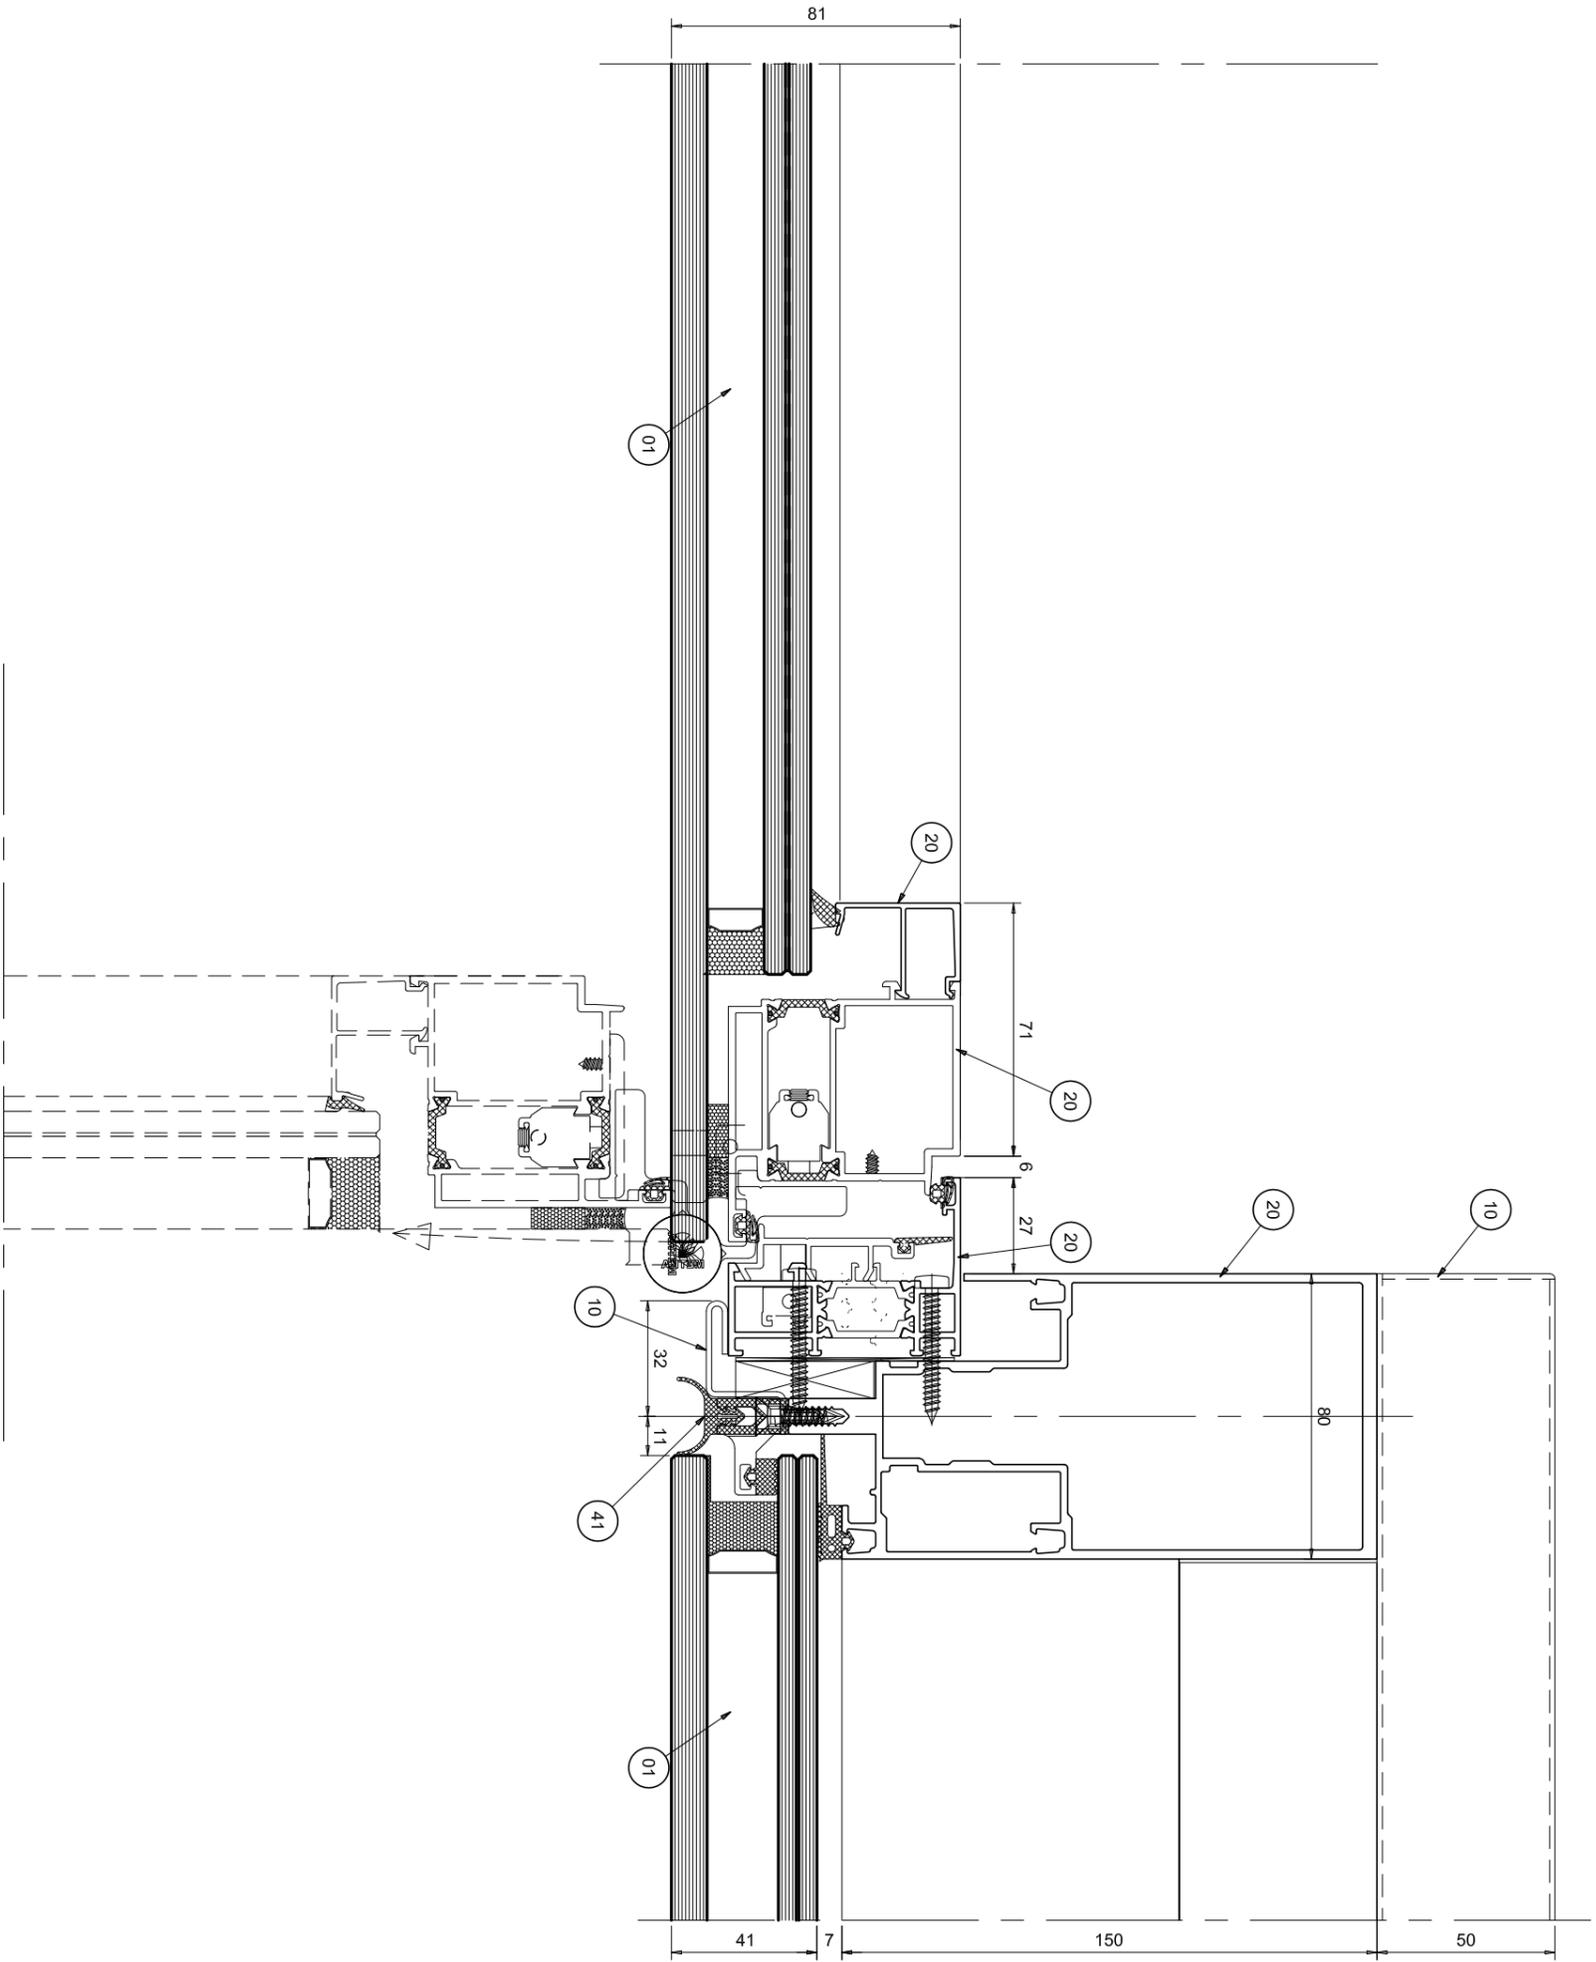

LEGEND	
Nº	MATERIAL
01	DOUBLE GLAZING UNIT OUTER LITE: 10mm, TOUGHENED HST INNER LITE: 5,2 CLEAR FLOAT ACOUSTIC PVB INNER LITE: 5,2 CLEAR FLOAT ACOUSTIC PVB TOUGHENED HST
02	SINGLE GLASS CLEAR FLOAT 10mm th TOUGHENED HST DRENILED COLOR BAL...
03	LAMINATED GLASS CLEAR FLOAT BR-4 TOUGHENED HST
10	ALUMINIUM SHEET 15/10 th
11	STAINLESS STEEL SHEET
12	GALVANIZED STEEL SHEET 15/10 th
13	GALVANIZED STEEL BRACKETS
20	ALUMINIUM EXTRUSIONS FOR C.W. PROFILES
30	STAINLESS STEEL SCREW
31	GALVANIZED STEEL SCREW
32	GALVANIZED STEEL BOLTS
33	EXPANSION BOLT
40	SILICONE DC 796 BLACK
41	EPDM EXTRUSION GASKET COLOR BLACK
42	SILICONE EXTRUSION GASKET COLOR BLACK
43	ROCK WOOL
44	1,5 mm thk ADHESIVE RUBBER MEMBRANE
45	RAISED FLOOR FINISH
46	CONCRETE SLAB
47	STEEL COLUMN
48	ALUMINIUM BORDER
49	STONE/CERAMIC FLOOR TILES
50	GYPSUM PLASTERBOARD FINISH
51	HALFEN SYSTEM SUPPORT
52	INTERNAL TEXTILE BLIND
53	ALUMINIUM SHEET 20/10 th

File : 926_Ae_07_107

Issue :
Main Project

Scale :
1:2

j.n.
926/09

Detail: H-003


Rev.:
-

Title :


The Curtain wall Glazing Facade - Ground floor
Elevation and section

Page:


5

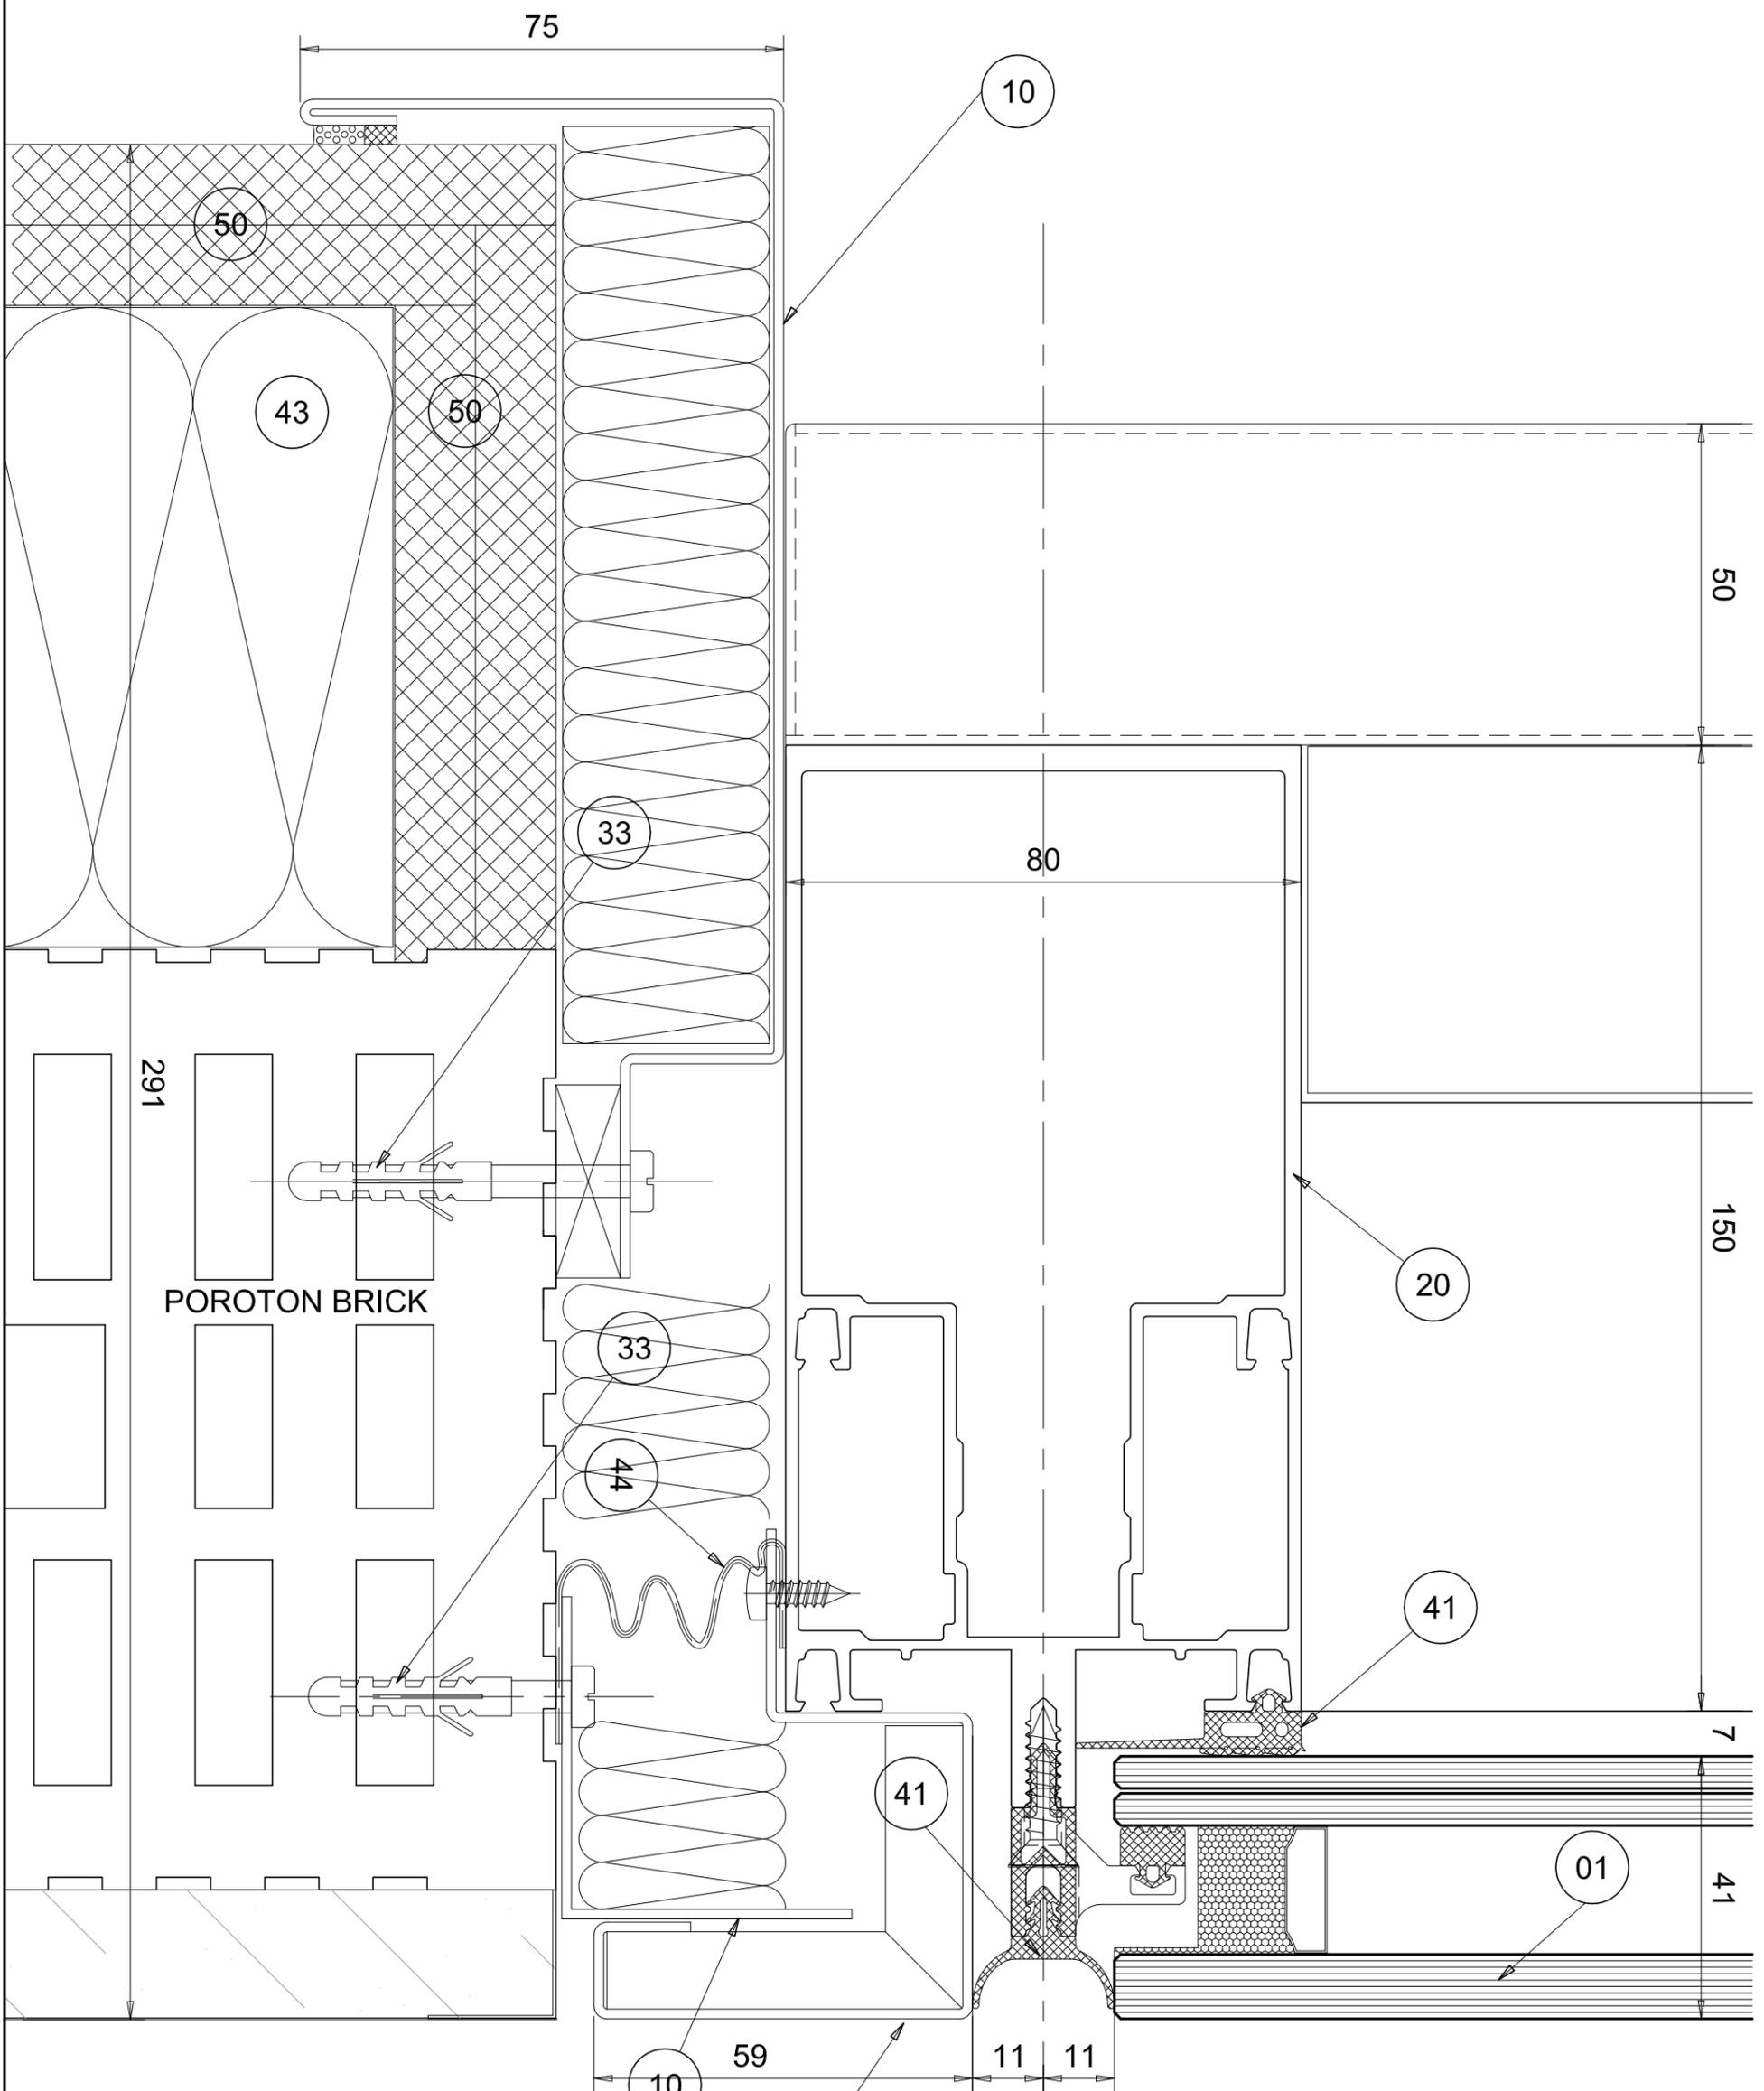


LEGEND	
Nº	MATERIAL
01	DOUBLE GLAZING UNIT GLASS: 10mm CLEAR TONED HST SPACER: 20mm ARGON 90% HE INNER LITE: 5x2 CLEAR FLOAT ACOUSTIC PWB OUTER LITE: 5x2 CLEAR FLOAT ACOUSTIC PWB DIVIDED COLOR RAL...
02	SINGLE GLASS CLEAR FLOAT 10mm th TOUNCHED HST
03	LAMINATED GLASS CLEAR FLOAT 88.4 TOUNCHED HST
10	ALUMINIUM SHEET 15/10 th
11	STAINLESS STEEL SHEET
12	GALVANIZED STEEL SHEET 15/10 th
13	GALVANIZED STEEL BRACKETS
20	ALUMINIUM EXTRUSIONS FOR C.W. PROFILES
30	STAINLESS STEEL SCREW
31	GALVANIZED STEEL SCREW
32	GALVANIZED STEEL BOLTS
33	EXPANSION BOLT
40	SILICONE DC 796 BLACK
41	EPDM EXTRUSION GASKET COLOR BLACK
42	SILICONE EXTRUSION GASKET COLOR BLACK
43	ROCK WOOL
44	1.5 mm thk ADHESIVE RUBBER MEMBRANE
45	RAISED FLOOR FINISH
46	CONCRETE SLAB
47	STEEL COLUMN
48	ALUMINIUM BORDER
49	STONE/CERAMIC FLOOR TILES
50	GYPSEUM PLASTERBOARD FINISH
51	HALTER SYSTEM SUPPORT
52	INTERNAL TEXTILE BLIND
53	ALUMINIUM SHEET 20/10 th

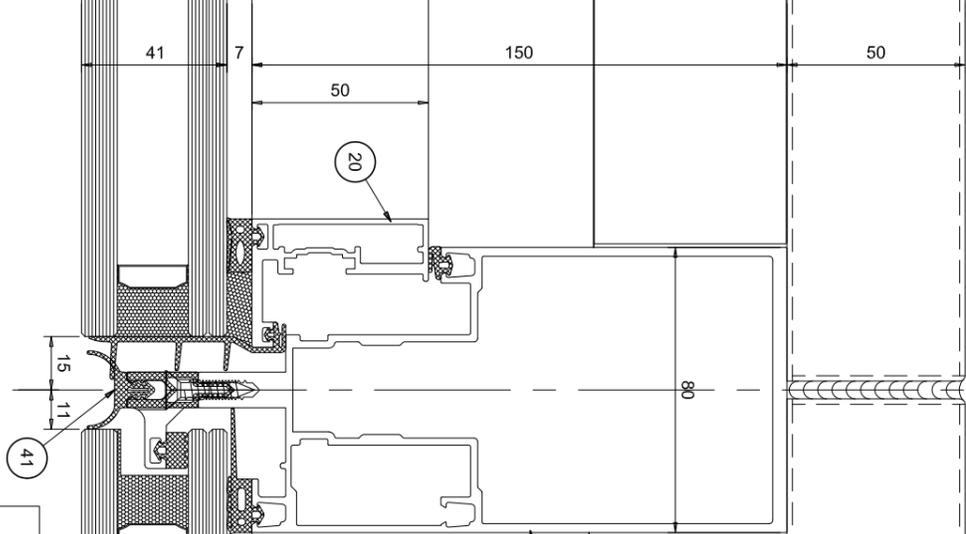

LEGEND	
Nr	MATERIAL
01	DOUBLE GLAZING UNIT OUTER LITE: 10mm TONED 55,2 CLEAR FLOAT ACUSTIC PVB INNER LITE: 55,2 CLEAR FLOAT ACUSTIC PVB TOUNDED HST EMBEDED COLOR PALL.
02	SINGLE GLASS CLEAR FLOAT 10mm th TOUNDED HST EMBEDED COLOR PALL.
03	LAMINATED GLASS CLEAR FLOAT 88,4 TOUNDED HST
10	ALUMINIUM SHEET 15/10 th
11	STAINLESS STEEL SHEET
12	GALVANIZED STEEL SHEET 15/10 th
13	GALVANIZED STEEL BRACKETS
20	ALUMINIUM EXTRUSIONS FOR C.W. PROFILES
30	STAINLESS STEEL SCREW
31	GALVANIZED STEEL SCREW
32	GALVANIZED STEEL BOLTS
33	EXPANSION BOLT
40	SILICONE DC 796 BLACK
41	EPDM EXTRUSION GASKET COLOR BLACK
42	SILICONE EXTRUSION GASKET COLOR BLACK
43	ROCK WOOL
44	1,5 mm thk ADHESIVE RUBBER MEMBRANE
45	RAISED FLOOR FINISH
46	CONCRETE SLAB
47	STEEL COLUMN
48	ALUMINIUM BORDER
49	STONE/CERAMIC FLOOR TILES
50	GYPSUM PLASTERBOARD FINISH
51	HALFEN SYSTEM SUPPORT
52	INTERNAL TEXTILE BLIND
53	ALUMINIUM SHEET 20/10 th

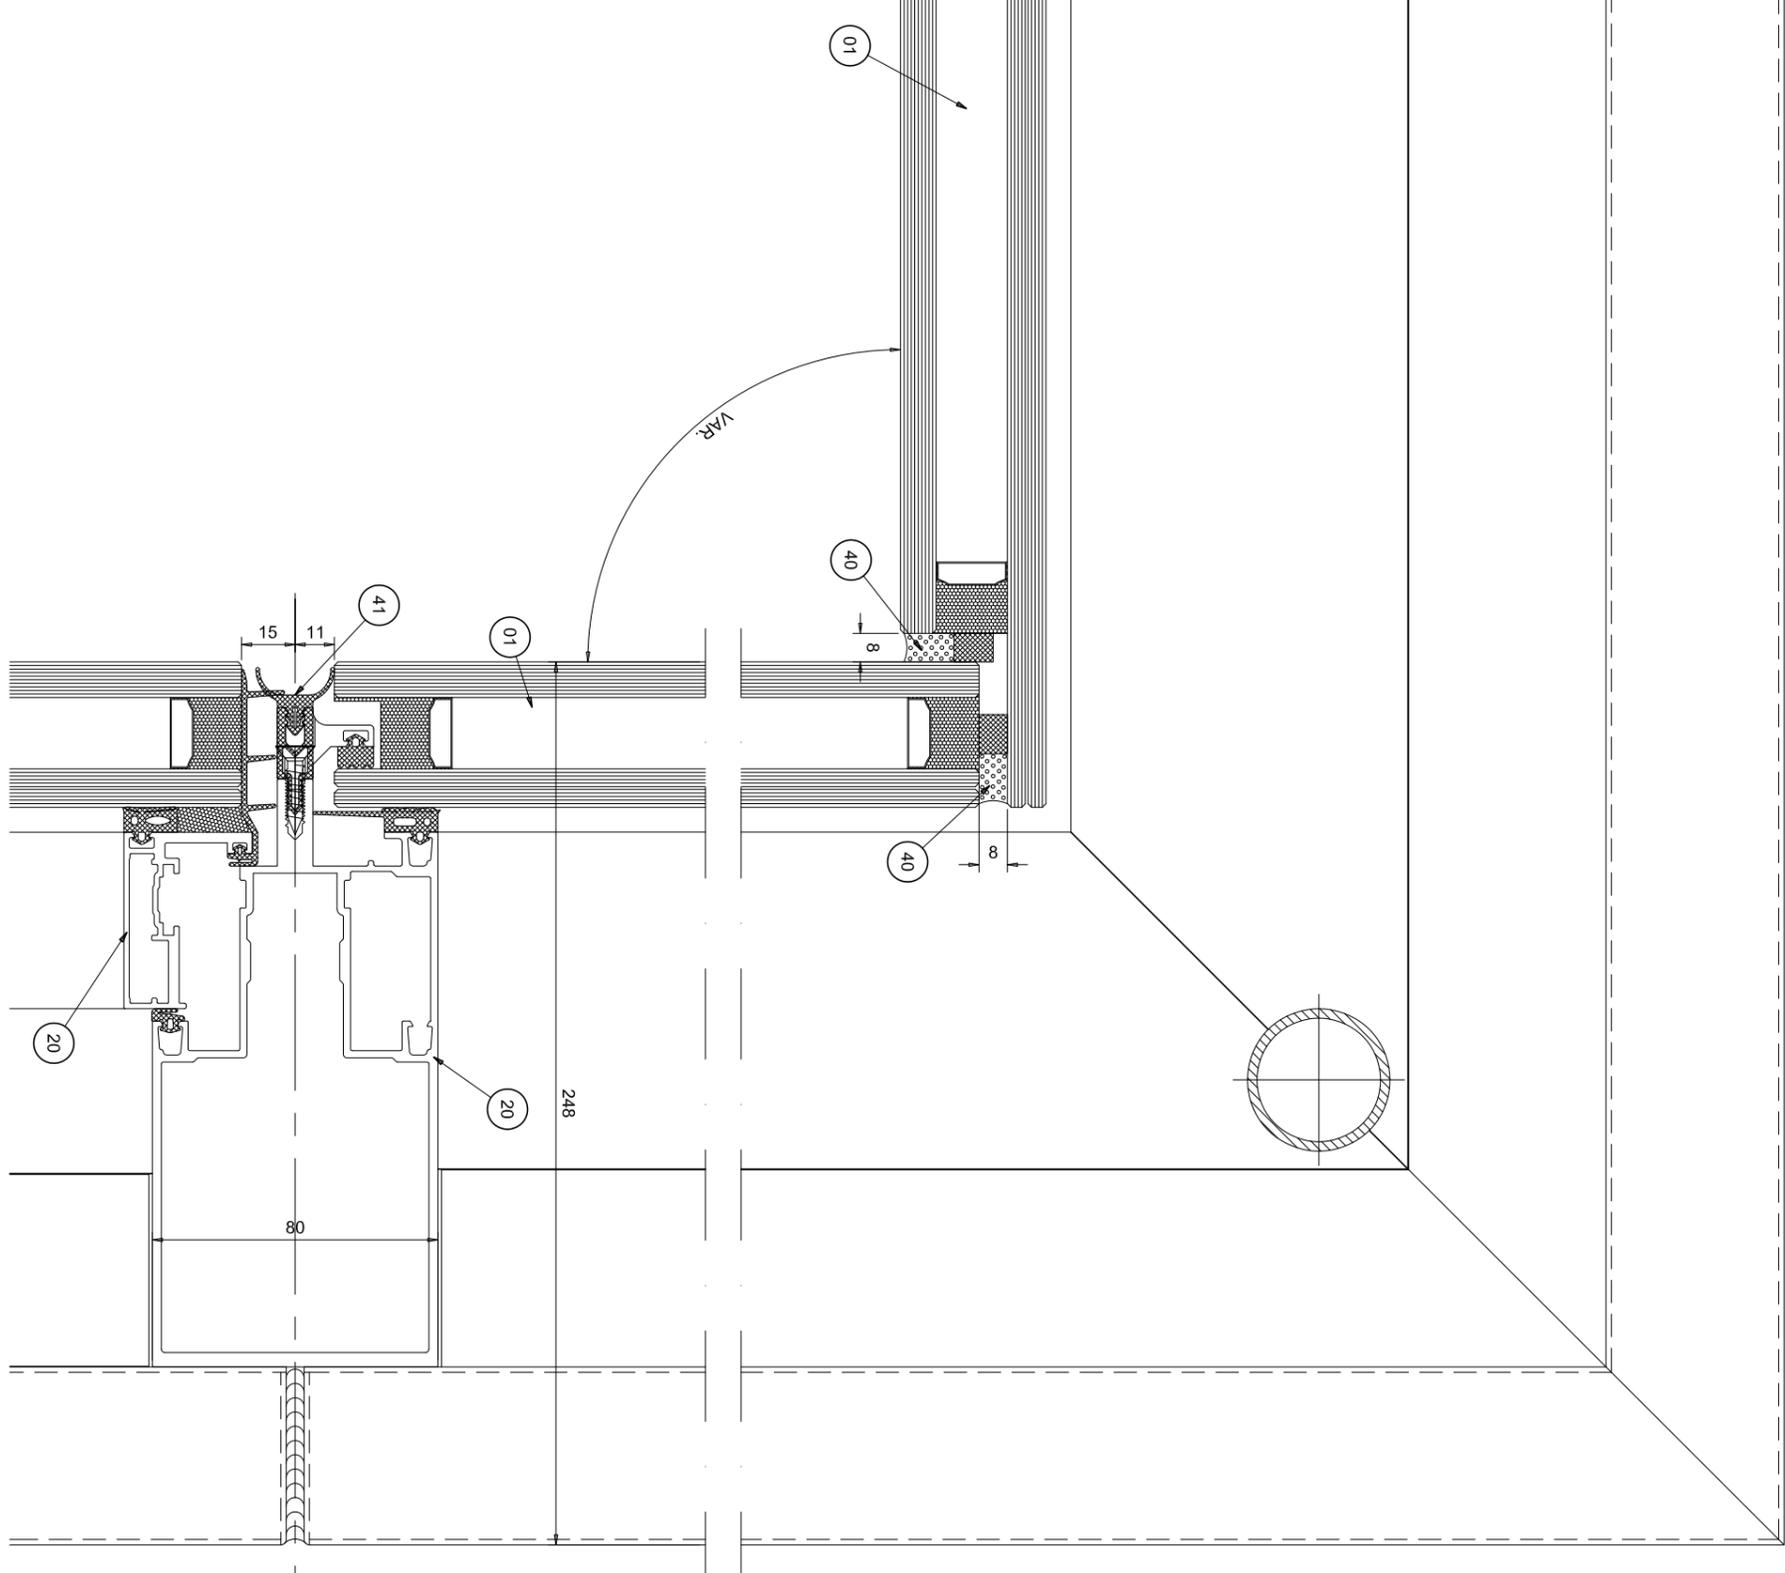

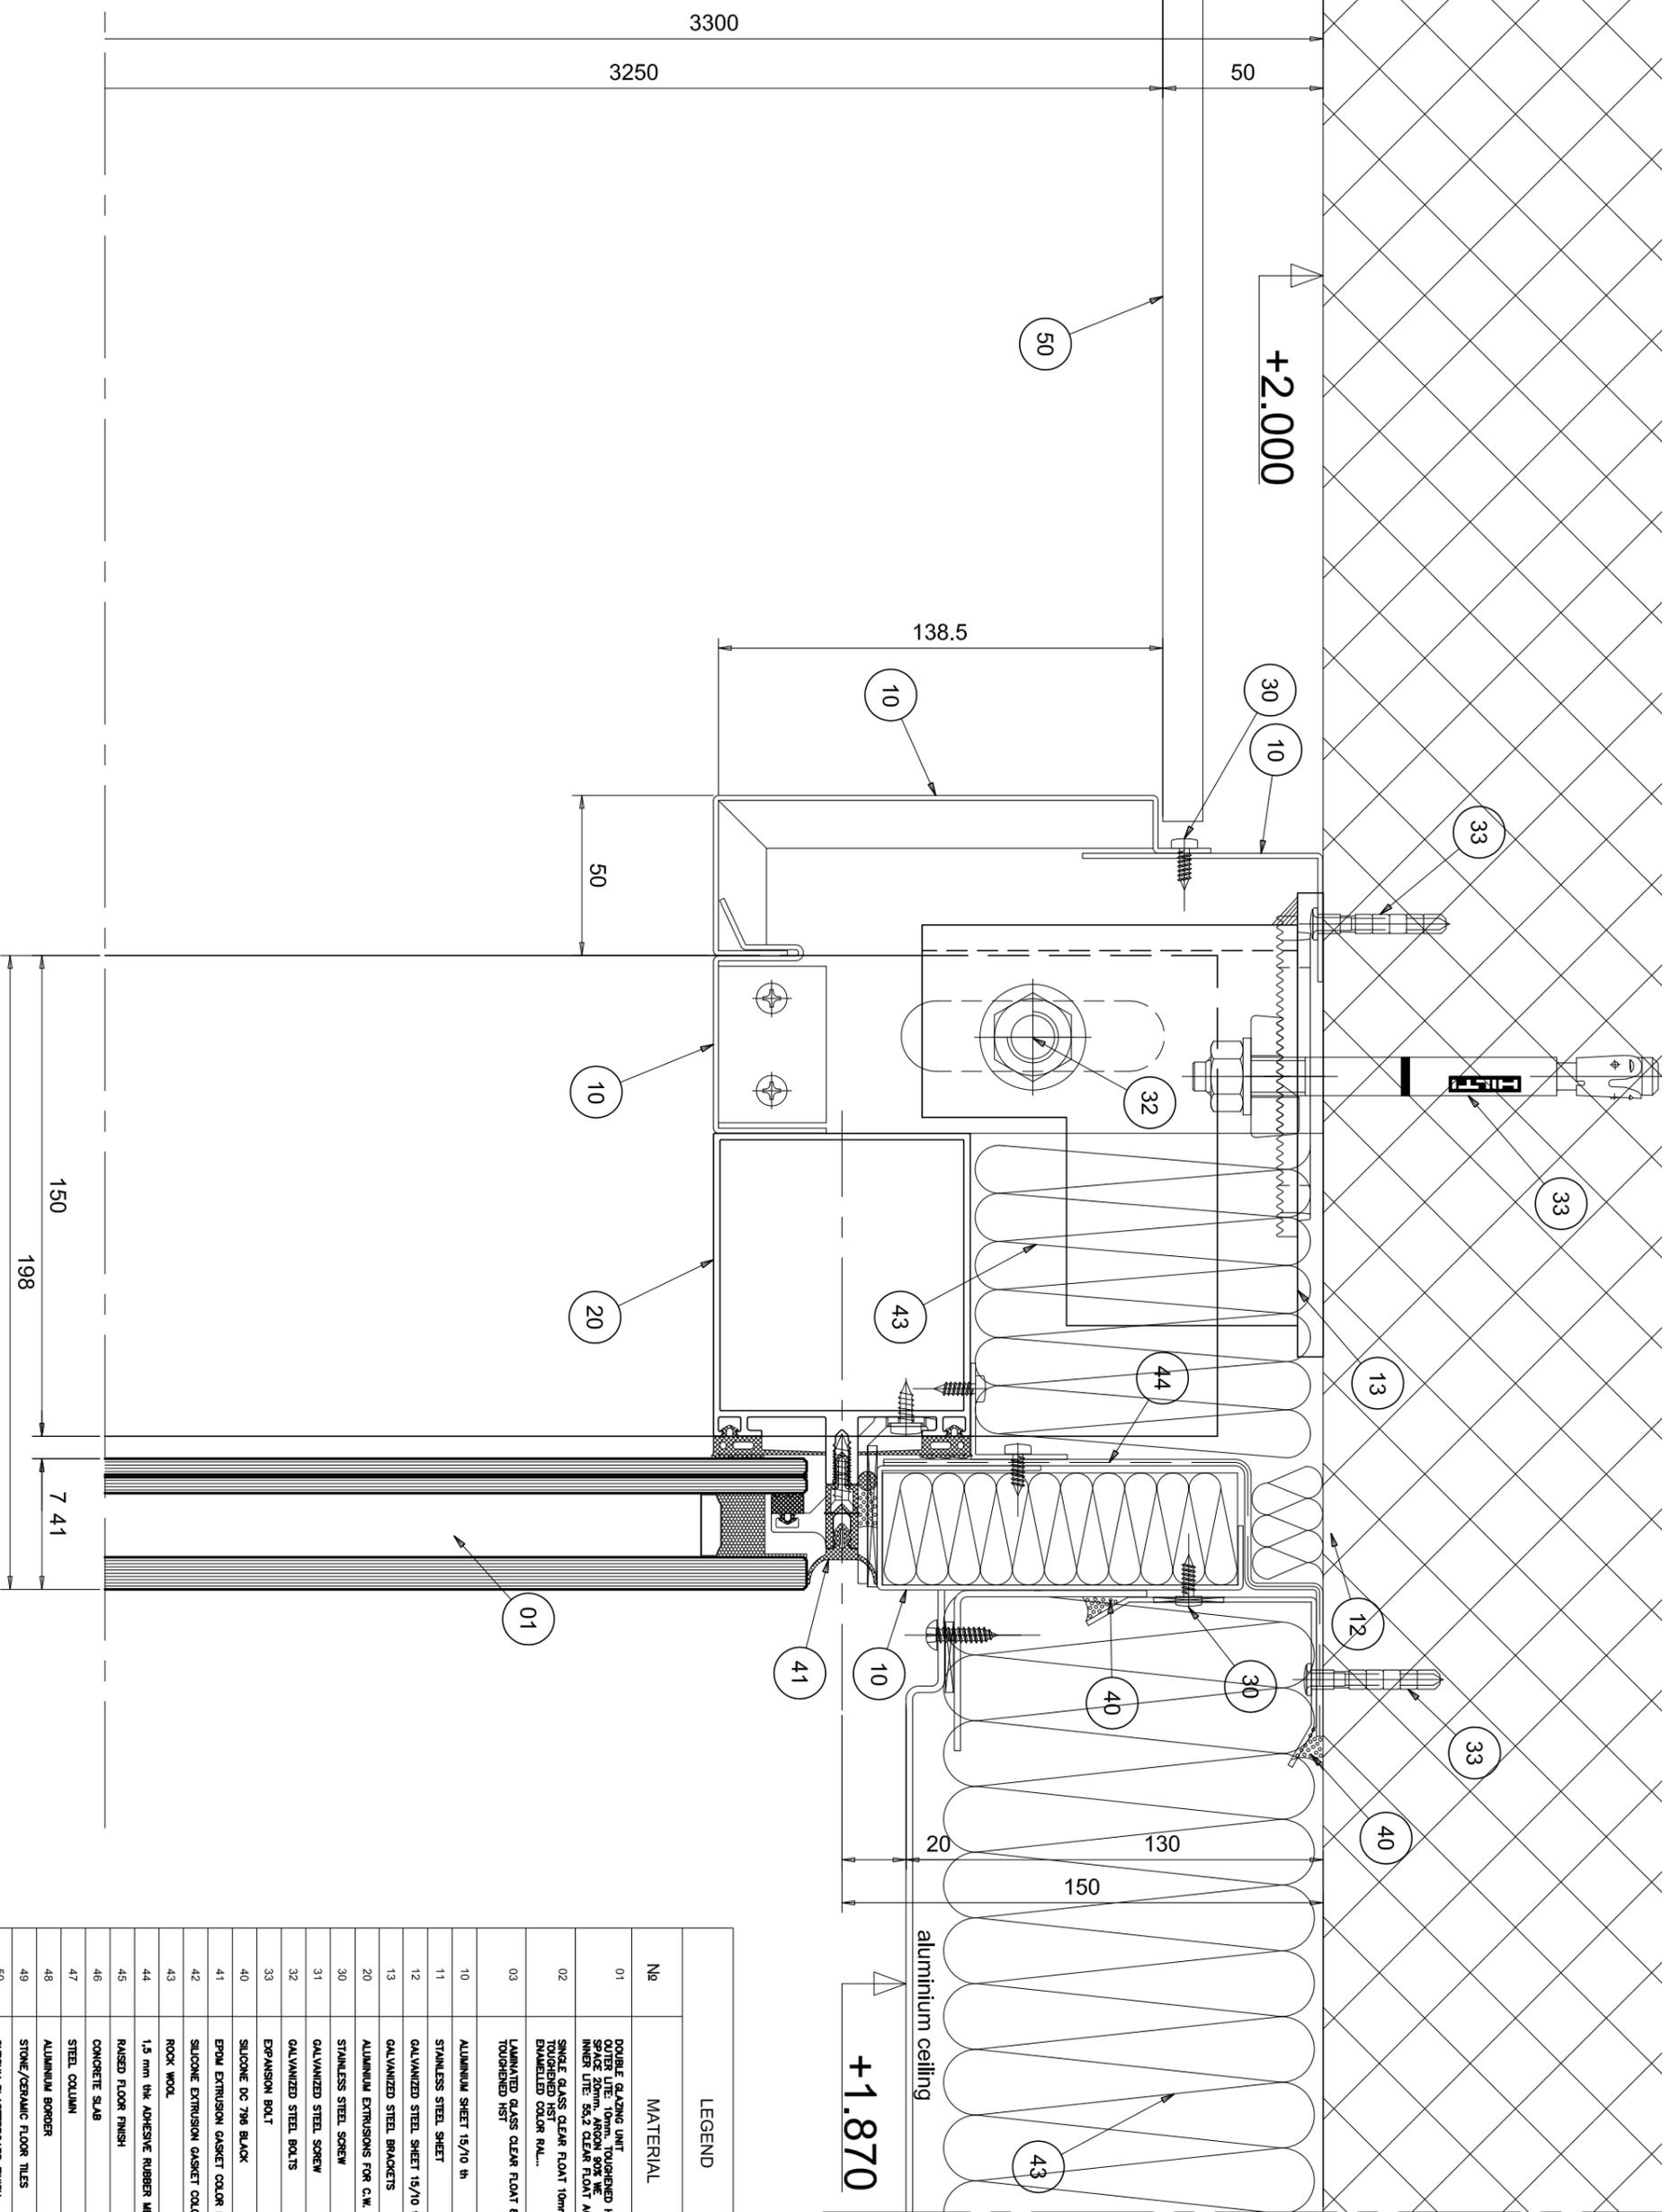

LEGEND	
Nº	MATERIAL
01	DOUBLE GLAZING UNIT OUTER LITE: 10mm, TOUGHENED HST INNER LITE: 5.2 CLEAR FLOAT ACOUSTIC PVB INTER LITE: 5.2 CLEAR FLOAT ACOUSTIC PVB
02	SINGLE GLASS CLEAR FLOAT 10mm th TOUGHENED HST EMBEDDED COLOR BAL...
03	LAMINATED GLASS CLEAR FLOAT BR-4 TOUGHENED HST
10	ALUMINIUM SHEET 15/10 th
11	STAINLESS STEEL SHEET
12	GALVANIZED STEEL SHEET 15/10 th
13	GALVANIZED STEEL BRACKETS
20	ALUMINIUM EXTRUSIONS FOR C.W. PROFILES
30	STAINLESS STEEL SCREW
31	GALVANIZED STEEL SCREW
32	GALVANIZED STEEL BOLTS
33	EXPANSION BOLT
40	SILICONE DC 796 BLACK
41	EPDM EXTRUSION GASKET COLOR BLACK
42	SILICONE EXTRUSION GASKET COLOR BLACK
43	ROCK WOOL
44	1.5 mm thk ADHESIVE RUBBER MEMBRANE
45	RAISED FLOOR FINISH
46	CONCRETE SLAB
47	STEEL COLUMN
48	ALUMINIUM BORDER
49	STONE/CERAMIC FLOOR TILES
50	GYPNUM PLASTERBOARD FINISH
51	HALFEN SYSTEM SUPPORT
52	INTERNAL TEXTILE BLIND
53	ALUMINIUM SHEET 20/10 th

File : 926_Ae_07_107

Issue : Main Project



Scale : 1:2

j.n. 926/09

Detail: V-001

Rev.: -


Title : The Curtain wall Glazing Facade - Ground floor
Section detail

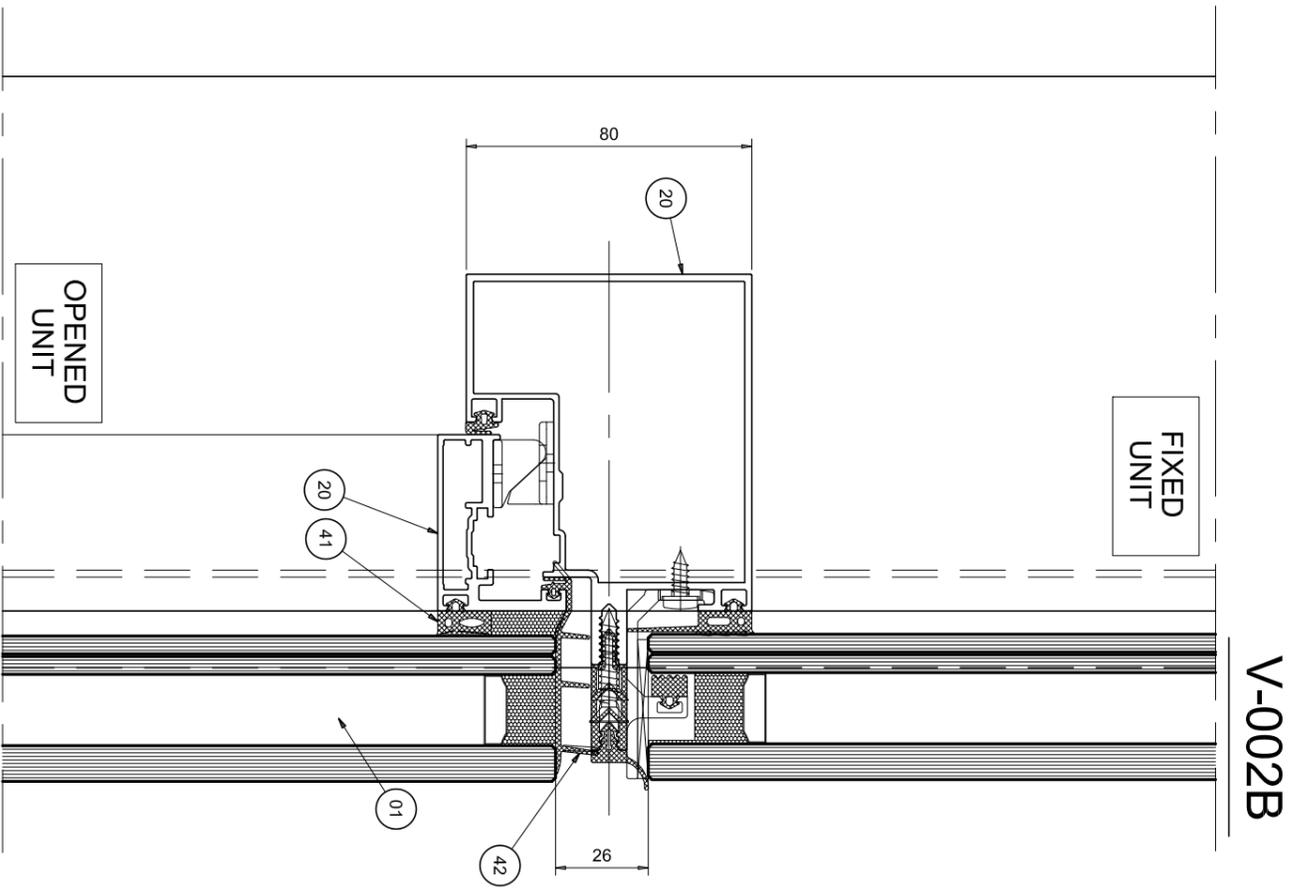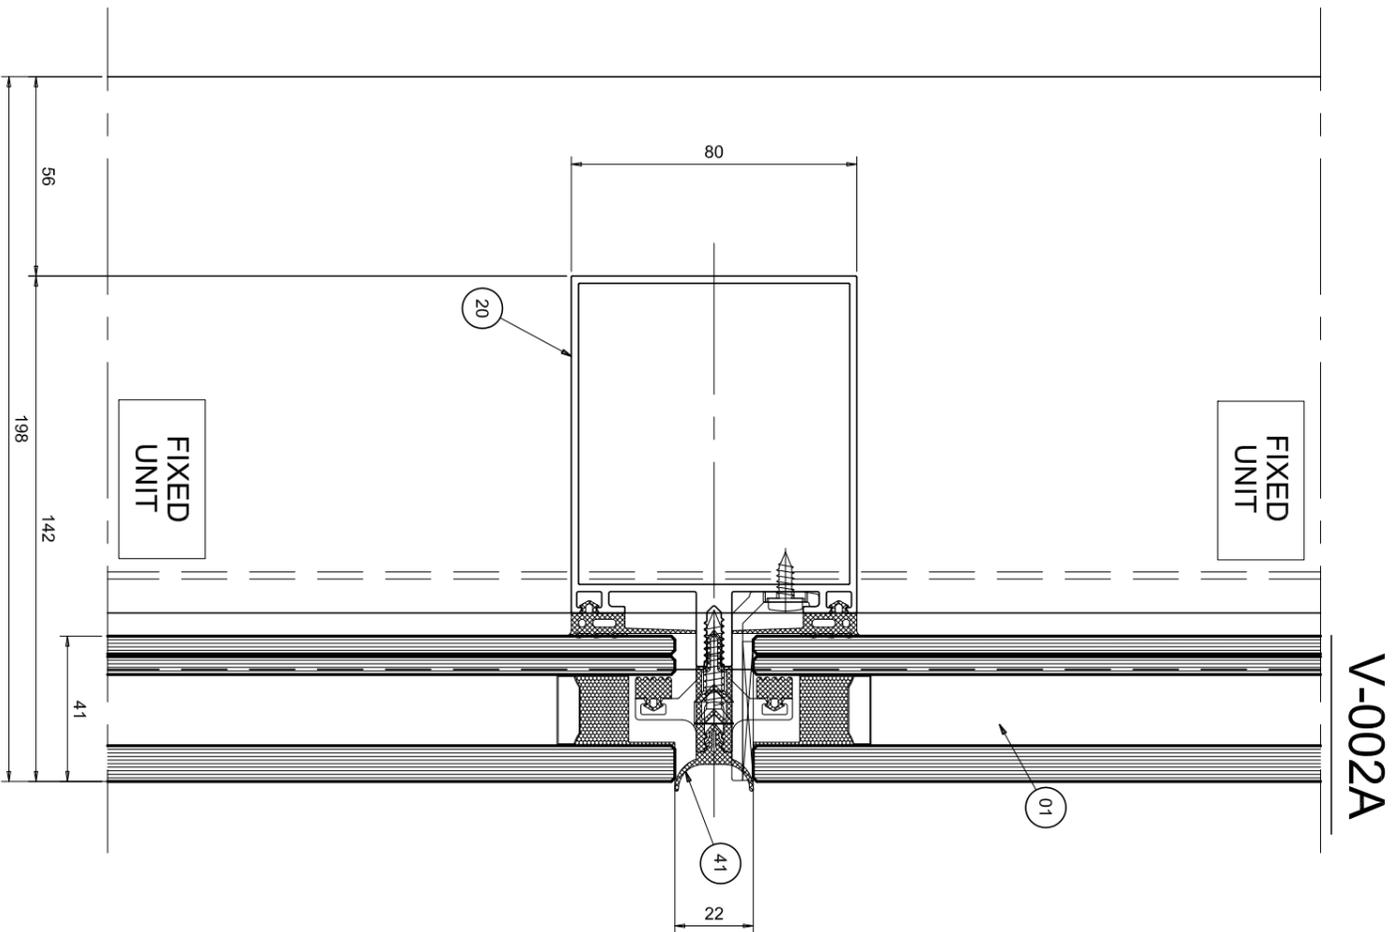

LEGEND	
Nº	MATERIAL
01	DOUBLE GLAZING UNIT OUTER LITE: 10mm, TOUGHENED HST INNER LITE: 5&2 CLEAR FLOAT ACOUSTIC PVB SPACER: 16mm ARGON
02	SINGLE GLASS CLEAR FLOAT 10mm th TOUGHENED HST DIMENSIONED COLOR BAL...
03	LAMINATED GLASS CLEAR FLOAT BR-4 TOUGHENED HST
10	ALUMINIUM SHEET 15/10 th
11	STAINLESS STEEL SHEET
12	GALVANIZED STEEL S
\ WOOL	
44	1,5 mm thk ADHESIVE RUBBER MEMBRANE
45	RAISED FLOOR FINISH
46	CONCRETE SLAB
47	STEEL COLUMN
48	ALUMINIUM BORDER
49	STONE/CERAMIC FLOOR TILES
50	GYPSUM PLASTERBOARD FINISH
51	HALFEN SYSTEM SUPPORT
52	INTERNAL TEXTILE BLIND
53	ALUMINIUM SHEET 20/10 th

V-002A

V-002B

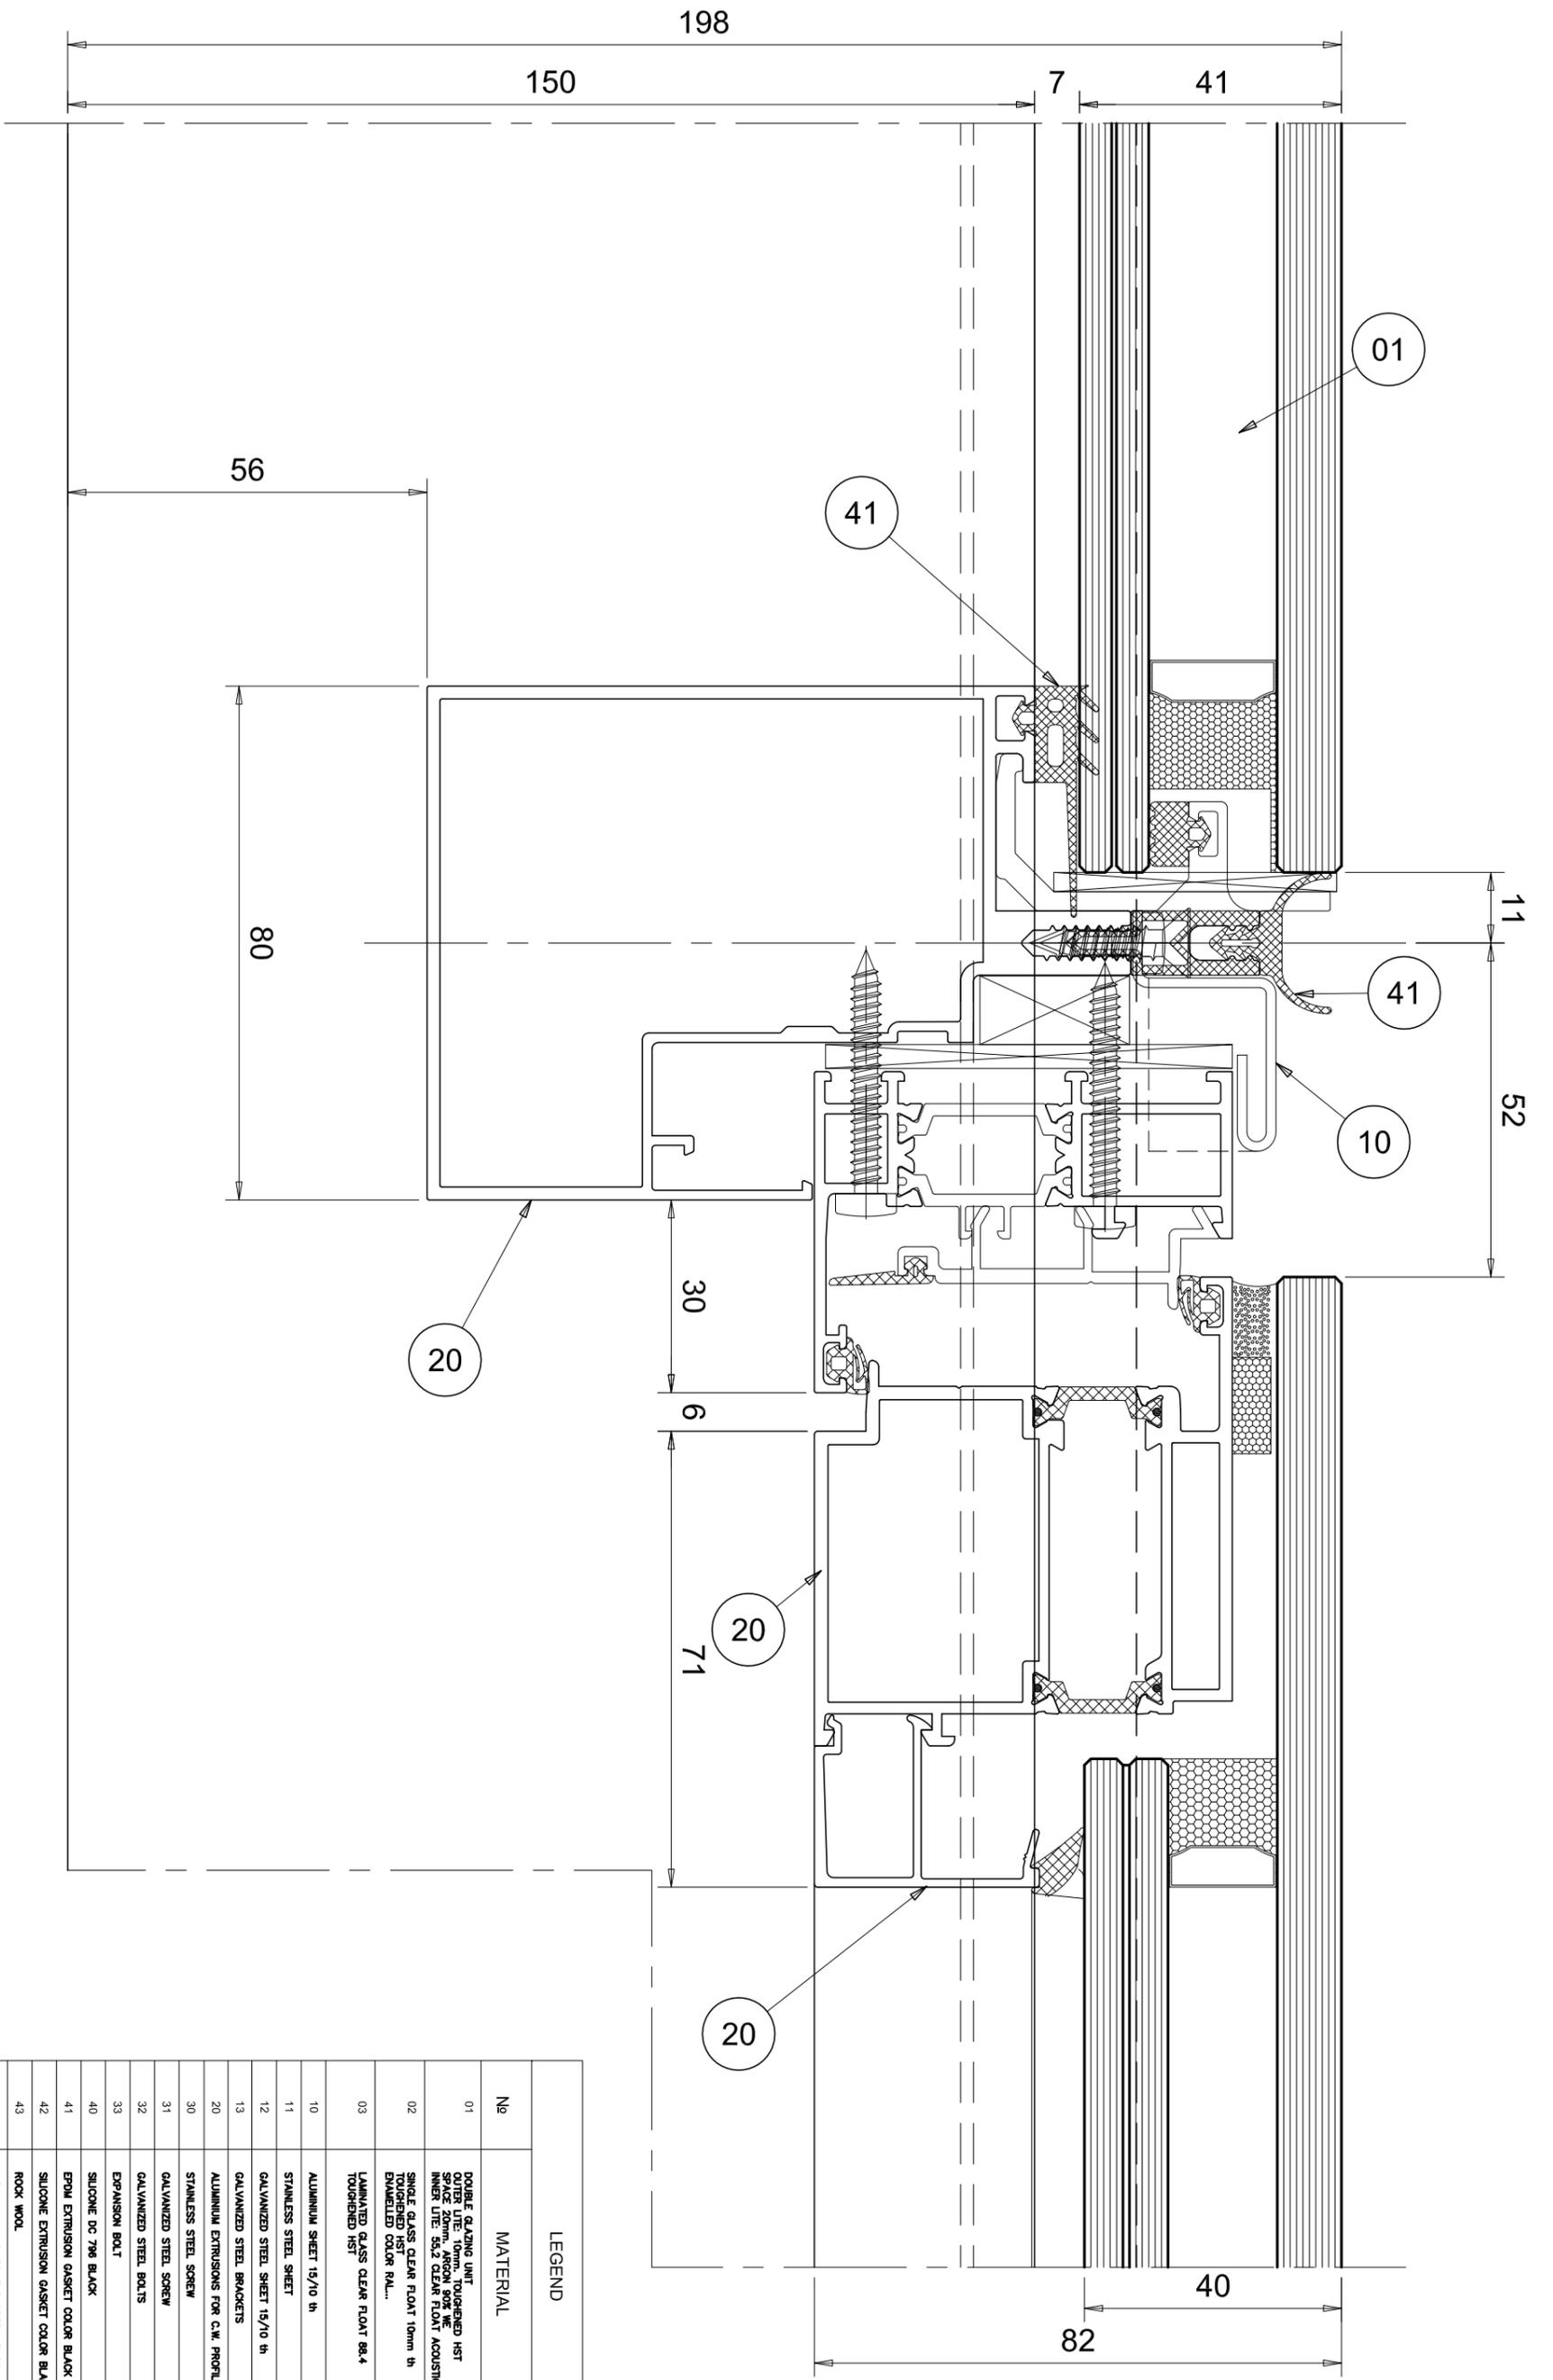

LEGEND	
Nº	MATERIAL
01	DOUBLE GLAZING UNIT OUTER LITE: 10mm, TOUGHENED HST SPACE 20mm, ARGON 90% WE INNER LITE: 55,2 CLEAR FLOAT ACOUSTIC PVB TOUGHENED HST EMBELLED COLOR PAL...
02	TOUGHENED HST EMBELLED COLOR PAL...
03	LAMINATED GLASS CLEAR FLOAT 88,4 TOUGHENED HST
10	ALUMINIUM SHEET 15/10 th
11	STAINLESS STEEL SHEET
12	GALVANIZED STEEL SHEET 15/10 th
13	GALVANIZED STEEL BRACKETS
20	ALUMINIUM EXTRUSIONS FOR C.W. PROFILES
30	STAINLESS STEEL SCREW
31	GALVANIZED STEEL SCREW
32	GALVANIZED STEEL BOLTS
33	EXPANSION BOLT
40	SILICONE DC 796 BLACK
41	EPDM EXTRUSION GASKET COLOR BLACK
42	SILICONE EXTRUSION GASKET COLOR BLACK
43	ROCK WOOL
44	1,5 mm thk ADHESIVE RUBBER MEMBRANE
45	RAISED FLOOR FINISH
46	CONCRETE SLAB
47	STEEL COLUMN
48	ALUMINIUM BORDER
49	STONE/CERAMIC FLOOR TILES
50	GYP-SIM PLASTERBOARD FINISH
51	HALTEN SYSTEM SUPPORT
52	INTERNAL TEXTILE BLIND
53	ALUMINIUM SHEET 20/10 th

File : 926_Ae_07_107

Issue :
Main Project

Scale :
1:2


j.n.
926/09

Detail:

V-003

Rev.:
-


Title :
The Curtain wall Glazing Facade - Ground floor
Section detail

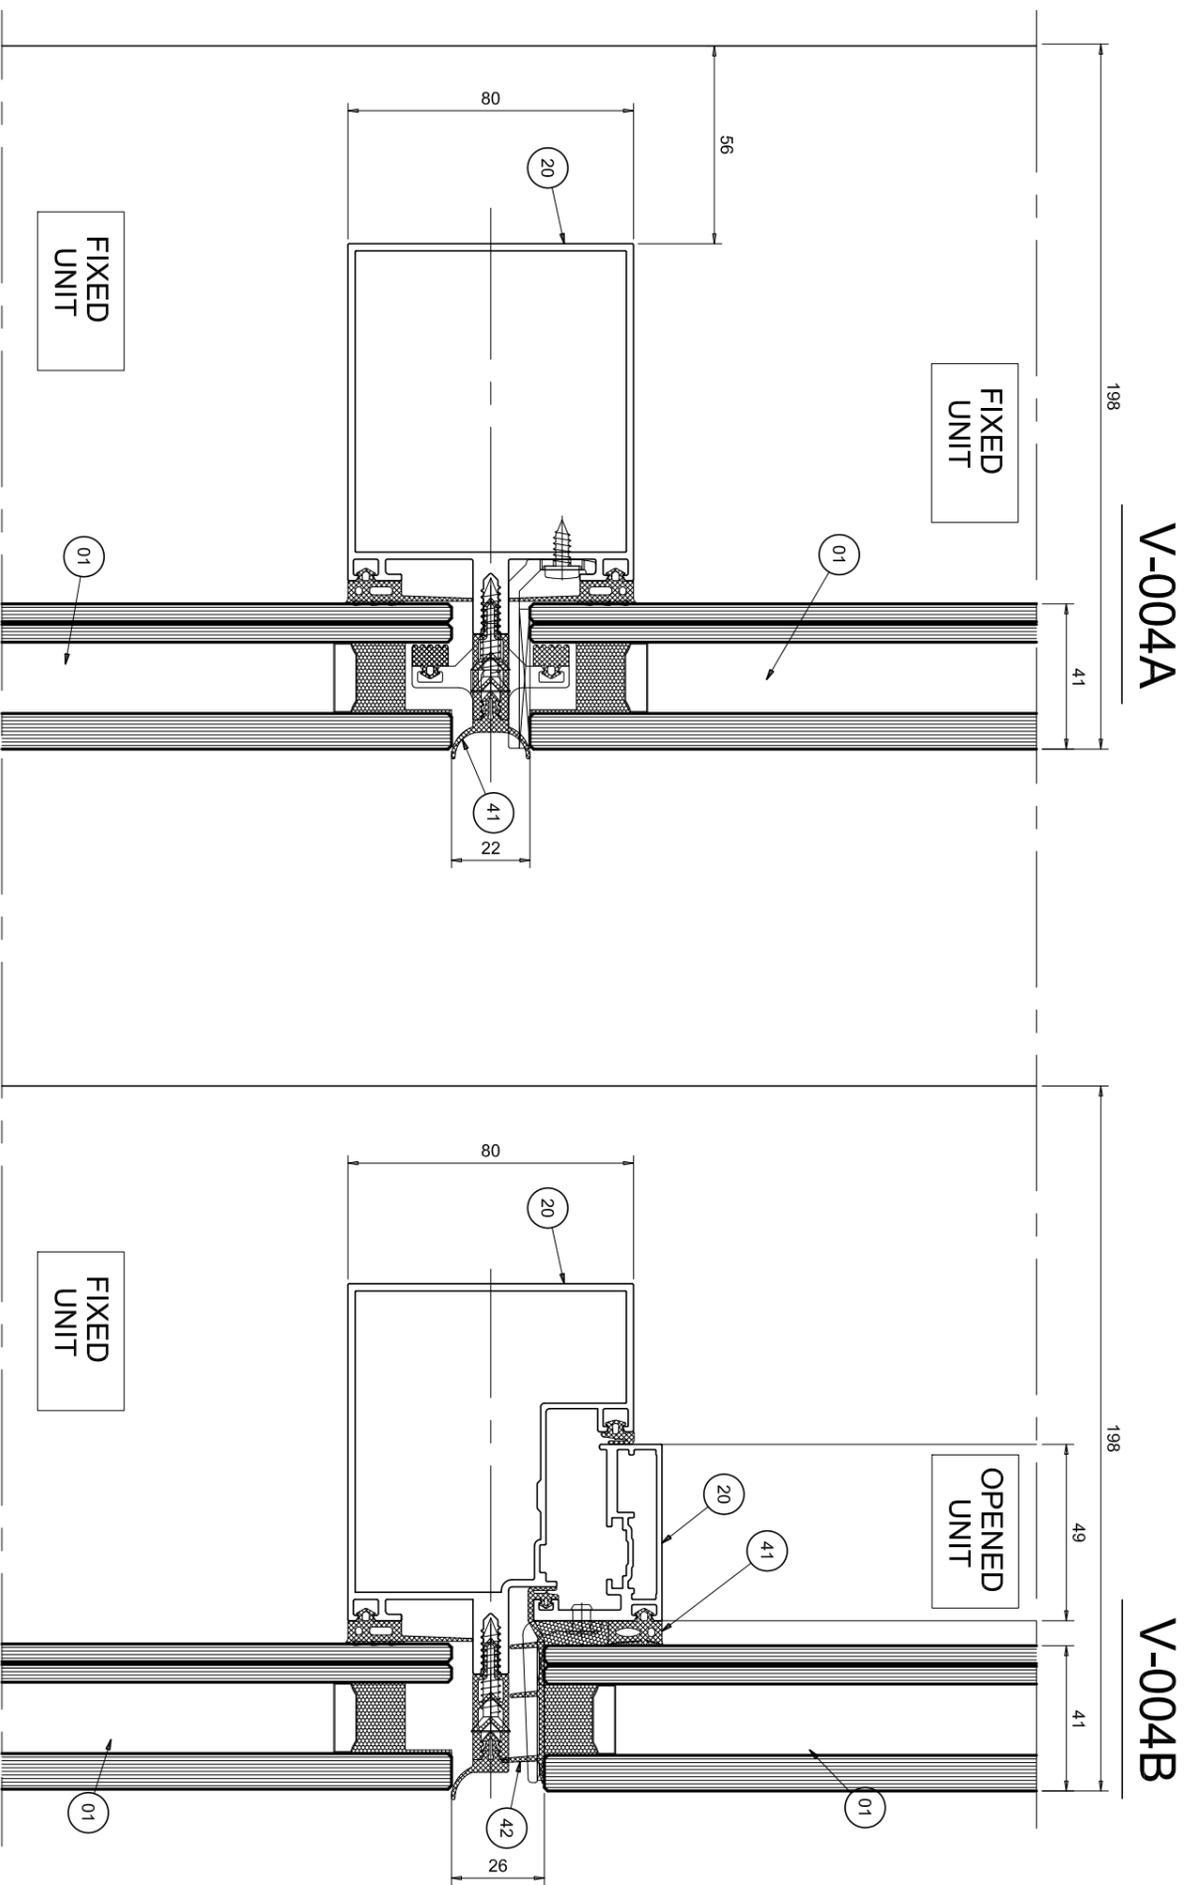

LEGEND	
Nº	MATERIAL
01	DOUBLE GLAZING UNIT OUTER LITE: 10mm, TOUGHENED HST INNER LITE: 5&2 CLEAR FLOAT ACOUSTIC PVB INNER LITE: 5&2 CLEAR FLOAT ACOUSTIC PVB TOUGHENED HST
02	SINGLE GLASS CLEAR FLOAT 10mm th TOUGHENED HST DRENKEL COLOR BAL...
03	LAMINATED GLASS CLEAR FLOAT BR.4 TOUGHENED HST
10	ALUMINIUM SHEET 1&10 th
11	STAINLESS STEEL SHEET
12	GALVANIZED STEEL SHEET 1&10 th
13	GALVANIZED STEEL BRACKETS
20	ALUMINIUM EXTRUSIONS FOR C.W. PROFILES
30	STAINLESS STEEL SCREW
31	GALVANIZED STEEL SCREW
32	GALVANIZED STEEL BOLTS
33	EXPANSION BOLT
40	SILICONE DC 79& BLACK
41	EPDM EXTRUSION GASKET COLOR BLACK
42	SILICONE EXTRUSION GASKET COLOR BLACK
43	ROCK WOOL
44	1,5 mm thk ADHESIVE RUBBER MEMBRANE
45	RAISED FLOOR FINISH
46	CONCRETE SLAB
47	STEEL COLUMN
48	ALUMINIUM BORDER
49	STONE/CERAMIC FLOOR TILES
50	GYPSUM PLASTERBOARD FINISH
51	HALFEN SYSTEM SUPPORT
52	INTERNAL TEXTILE BLIND
53	ALUMINIUM SHEET 20/10 th

File : 926_Ae_07_107		j.n.
Issue :	Scale :	926/09
Main Project	1:2	Rev.:
Detail:	V-004	-

Title : **The Curtain wall Glazing Facade - Ground floor**
Elevation and section

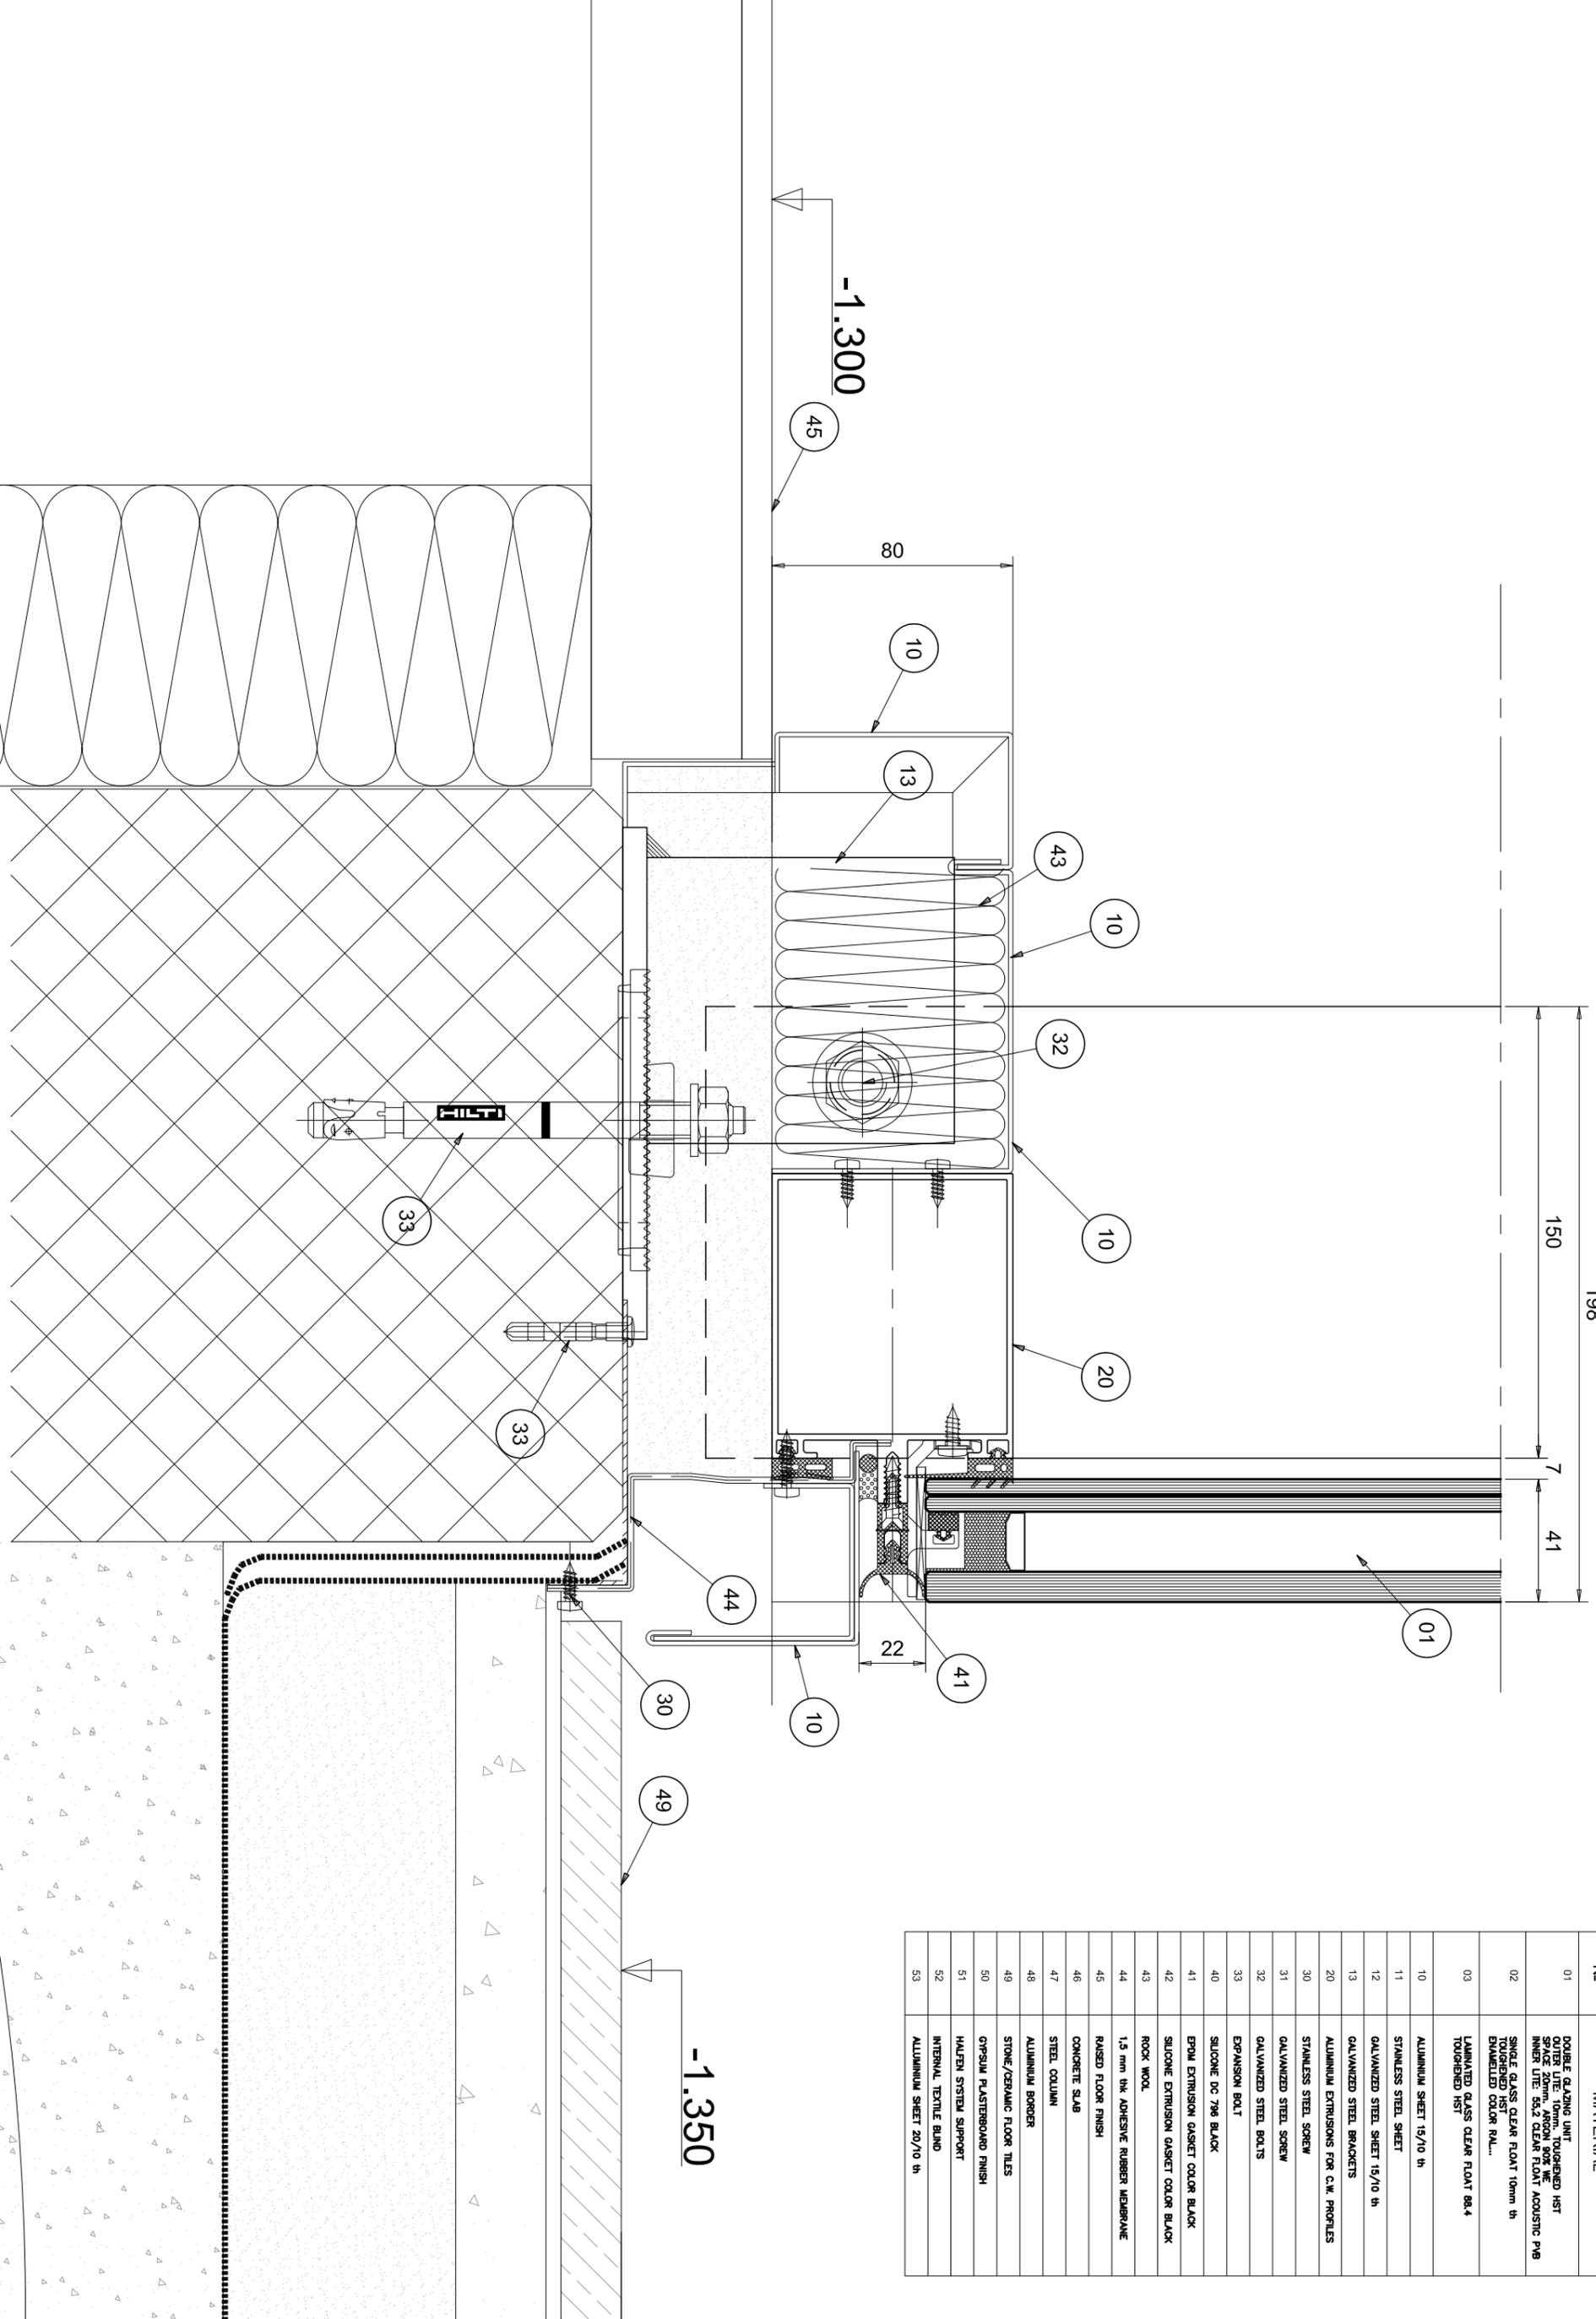


LEGEND	
Nº	MATERIAL
01	DOUBLE GLAZING UNIT OUTER LITE: 10mm, TOUGHENED HST INNER LITE: 5&2 CLEAR FLOAT ACOUSTIC PVB INTERLAYER: 5&2 CLEAR FLOAT ACOUSTIC PVB TOUGHENED HST
02	SINGLE GLASS CLEAR FLOAT 10mm th TOUGHENED HST DRENCHED COLOR BAL...
03	LAMINATED GLASS CLEAR FLOAT BR-4 TOUGHENED HST
10	ALUMINIUM SHEET 1&10 th
11	STAINLESS STEEL SHEET
12	GALVANIZED STEEL SHEET 1&10 th
13	GALVANIZED STEEL BRACKETS
20	ALUMINIUM EXTRUSIONS FOR C.W. PROFILES
30	STAINLESS STEEL SCREW
31	GALVANIZED STEEL SCREW
32	GALVANIZED STEEL BOLTS
33	EXPANSION BOLT
40	SILICONE DC 79& BLACK
41	EPDM EXTRUSION GASKET COLOR BLACK
42	SILICONE EXTRUSION GASKET COLOR BLACK
43	ROCK WOOL
44	1,5 mm thk ADHESIVE RUBBER MEMBRANE
45	RAISED FLOOR FINISH
46	CONCRETE SLAB
47	STEEL COLUMN
48	ALUMINIUM BORDER
49	STONE/CERAMIC FLOOR TILES
50	GYPSUM PLASTERBOARD FINISH
51	HALFEN SYSTEM SUPPORT
52	INTERNAL TEXTILE BLIND
53	ALUMINIUM SHEET 20/10 th

File : 926_Ae_07_107
 Issue : Main Project
 Detail: V-005
 Scale : 1:2
 j.n. 926/09
 Rev.: -






Title : The Curtain wall Glazing Facade - Ground floor
 Section detail

LEGEND	
Nº	MATERIAL
01	DOUBLE GLAZING UNIT SPACE 20mm. ARGON 90% WE INNER LITE: 55.2 CLEAR FLOAT ACOUSTIC PVB TOUGHENED COLOR RAL... OUTER LITE: 55.2 CLEAR FLOAT 10mm th
02	DOUBLE GLAZING UNIT SPACE 20mm. ARGON 90% WE INNER LITE: 55.2 CLEAR FLOAT ACOUSTIC PVB TOUGHENED COLOR RAL... OUTER LITE: 55.2 CLEAR FLOAT 10mm th
03	LAMINATED GLASS CLEAR FLOAT 88.4 TOUGHENED HST
10	ALUMINIUM SHEET 15/10 th
11	STAINLESS STEEL SHEET
12	GALVANIZED STEEL SHEET 15/10 th
13	GALVANIZED STEEL BRACKETS
20	ALUMINIUM EXTRUSIONS FOR C.W. PROFILES
30	STAINLESS STEEL SCREW
31	GALVANIZED STEEL SCREW
32	GALVANIZED STEEL BOLTS
33	EXPANSION BOLT
40	SILICONE DC 786 BLACK
41	EPDM EXTRUSION GASKET COLOR BLACK
42	SILICONE EXTRUSION GASKET COLOR BLACK
43	ROCK WOOL
44	1,5 mm th ADHESIVE RUBBER MEMBRANE
45	RAISED FLOOR FINISH
46	CONCRETE SLAB
47	STEEL COLUMN
48	ALUMINIUM BORDER
49	STONE/CERAMIC FLOOR TILES
50	GYPSUM PLASTERBOARD FINISH
51	HALTEN SYSTEM SUPPORT
52	INTERNAL TEXTILE BLIND
53	ALUMINIUM SHEET 20/10 th

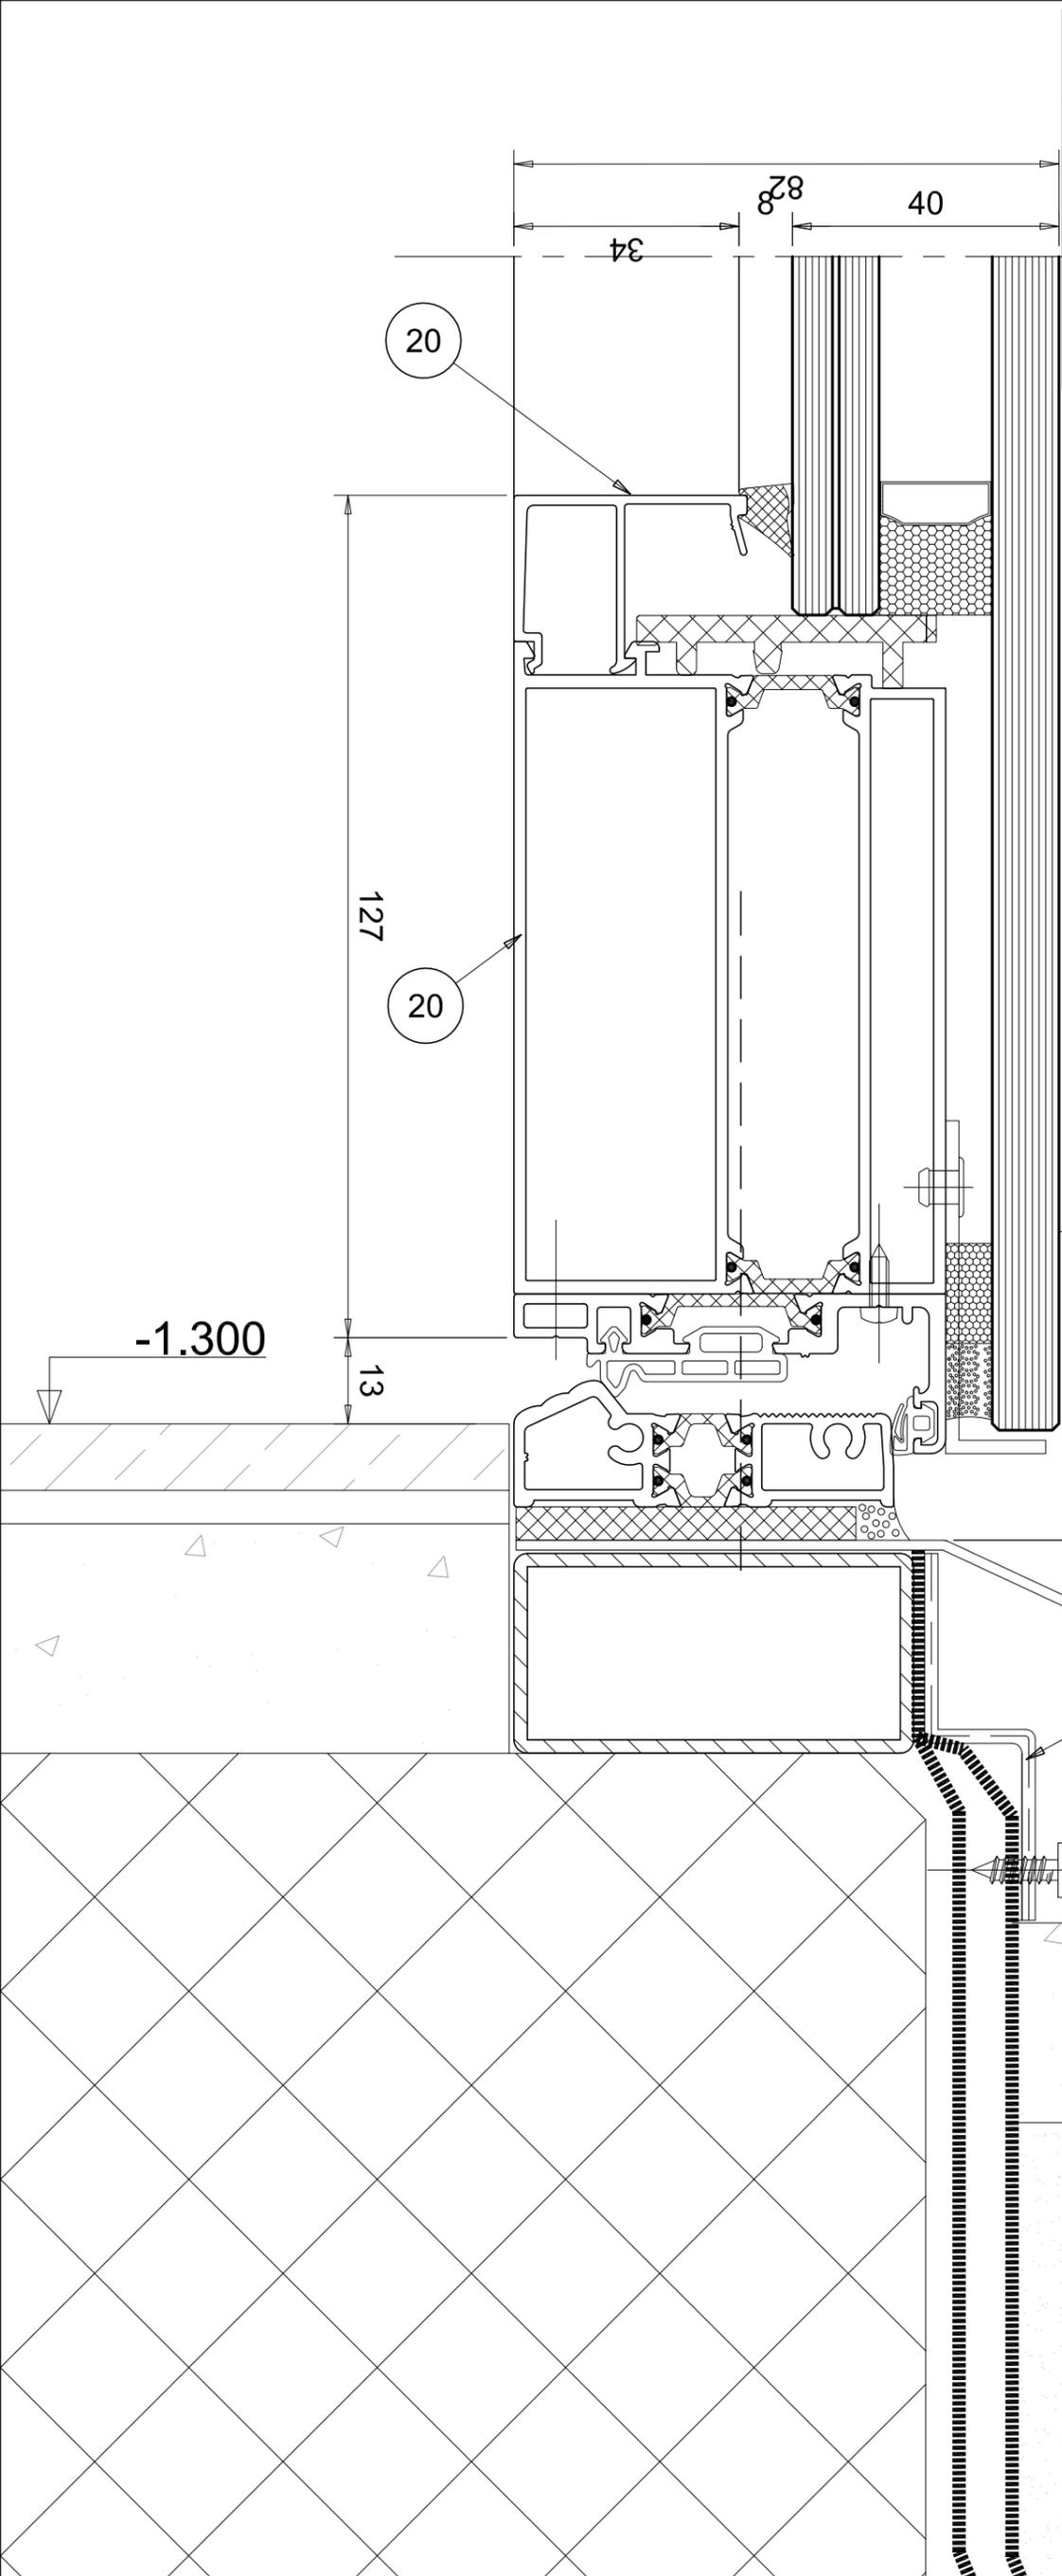


File : 926_Ae_07_107		
Issue :	Scale :	j.n.
Main Project	1:1	926/09
Detail:	V-006	Rev.: -

Title : **The Curtain wall Glazing Facade - Ground floor**
Section detail

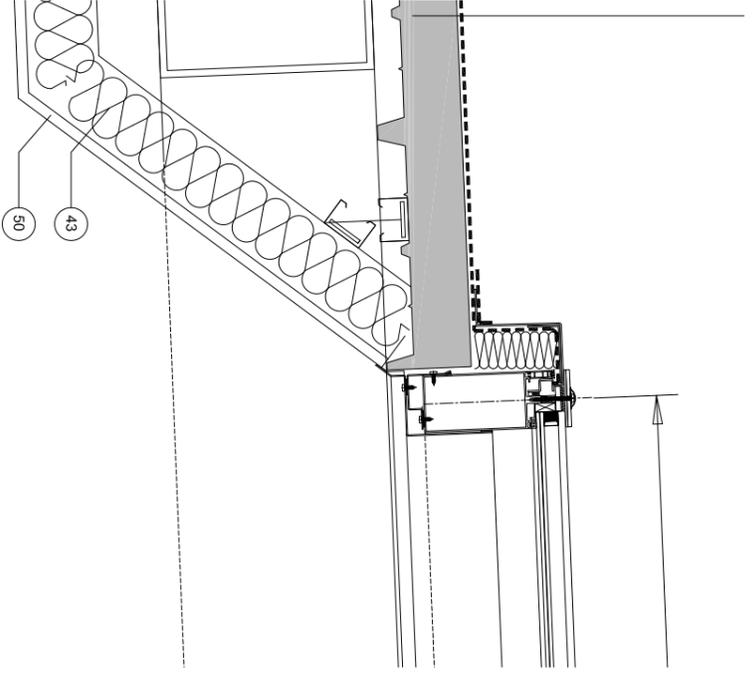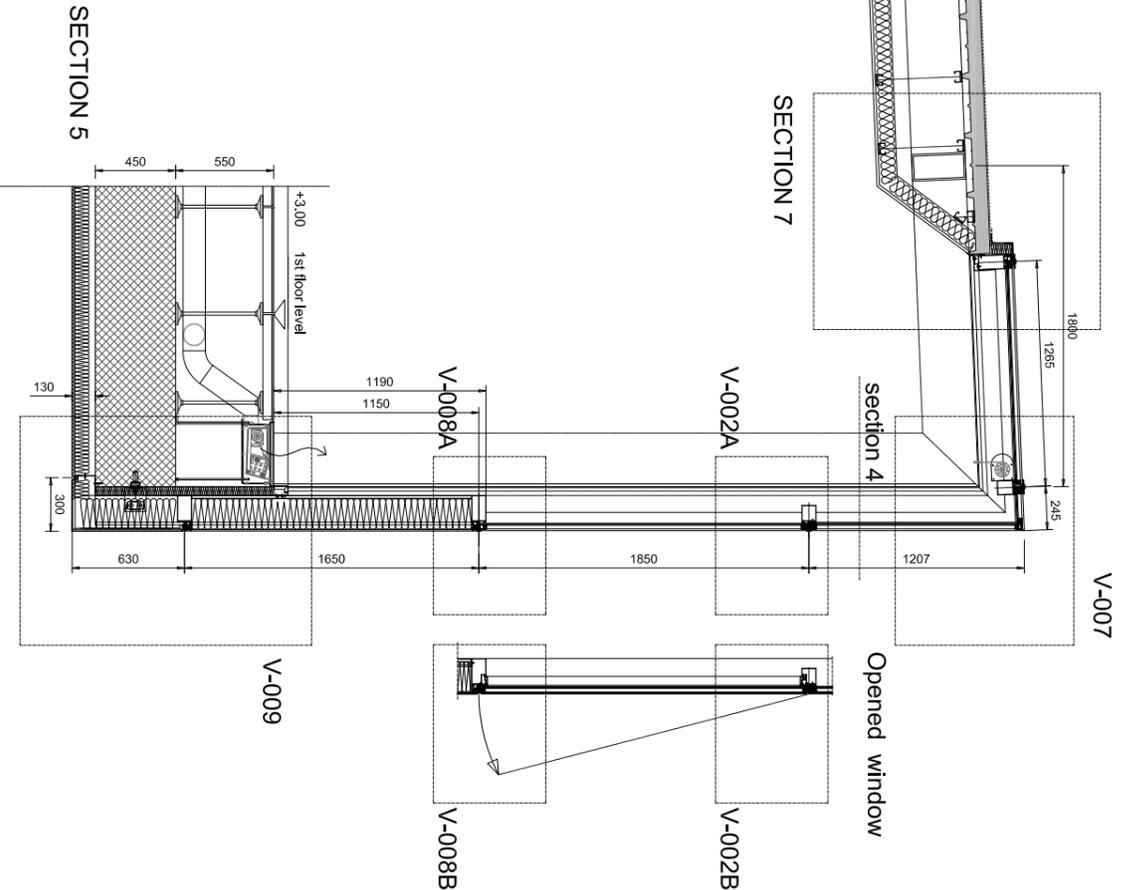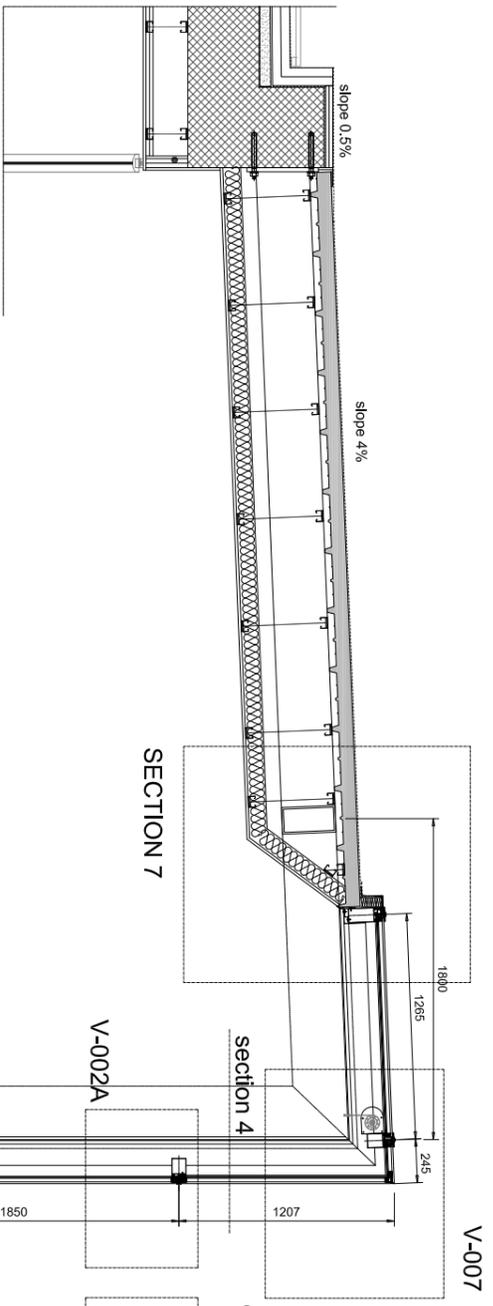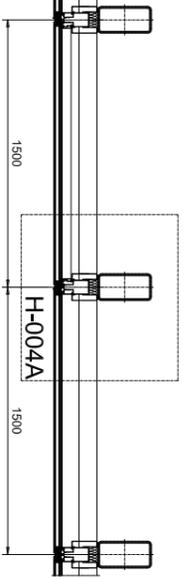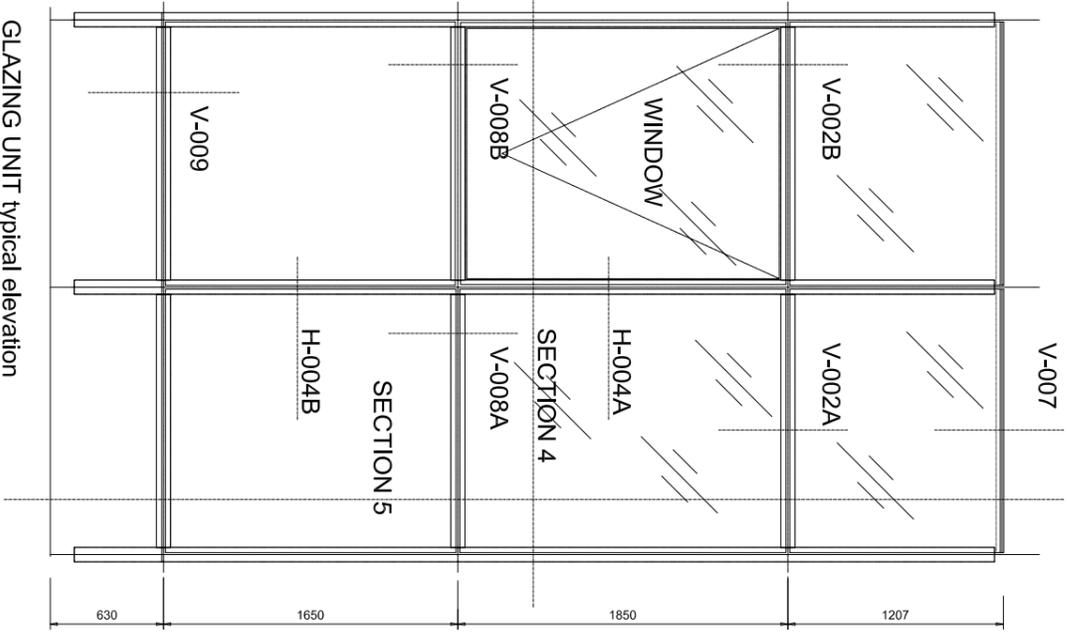


SECTION 7 scale 1:10

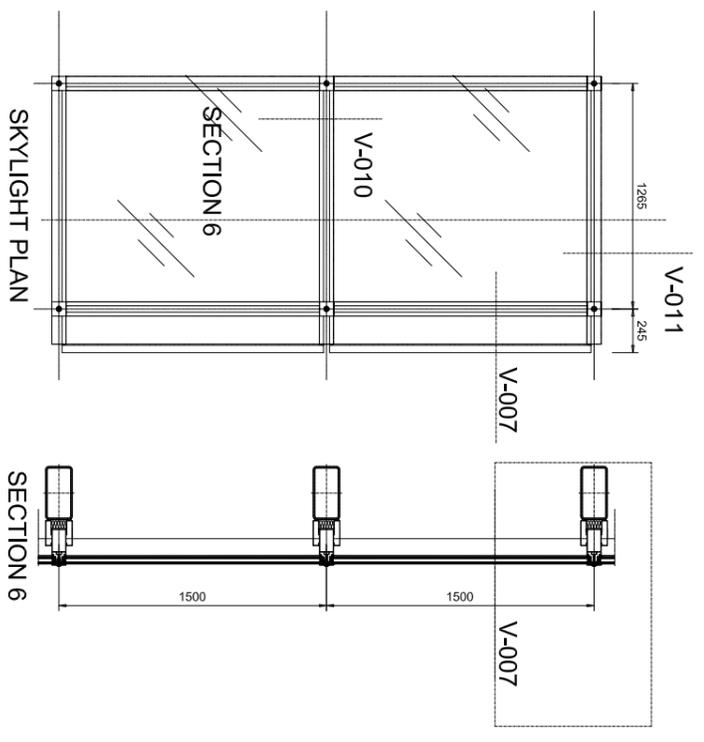

LEGEND	
No	MATERIAL
01	DOUBLE GLAZING UNIT OUTER LITE: TOPPER, TOUGHENED HST INNER LITE: 55.2 CLEAR FLOAT ACOUSTIC PVB
02	SINGLE GLASS CLEAR FLOAT 10mm th TOUGHENED HST ENAMELLED COLOR RAL...
03	LAMINATED GLASS CLEAR FLOAT 88.4 TOUGHENED HST
10	ALUMINIUM SHEET 15/10 th
11	STAINLESS STEEL SHEET
12	GALVANIZED STEEL SHEET 15/10 th
13	GALVANIZED STEEL BRACKET'S
20	ALUMINIUM EXTRUSIONS FOR C.W. PROFILES
30	STAINLESS STEEL SCREW
31	GALVANIZED STEEL SCREW
32	GALVANIZED STEEL BOLTS
33	EXPANSION BOLT
40	SILICONE DC 796 BLACK
41	EPDM EXTRUSION GASKET COLOR BLACK
42	SILICONE EXTRUSION GASKET COLOR BLACK
43	ROCK WOOL
44	1.5 mm th. ADHESIVE RUBBER MEMBRANE
45	RAISED FLOOR FINISH
46	CONCRETE SLAB
47	STEEL COLUMN
48	ALUMINIUM BORDER
49	STONE/CERAMIC FLOOR TILES
50	GYP'SUM PLASTERBOARD FINISH
51	HALFEN SYSTEM SUPPORT
52	INTERNAL TEXTILE BLIND
53	ALUMINIUM SHEET 20/10 th

File : 926_Ae_07_107		j.n.
Issue :	Scale :	926/09
Main Project	1:40	Rev.:
Detail:	EL-002	-

Title : **The Curtain wall Glazing Facade - First floor**
Elevation and section

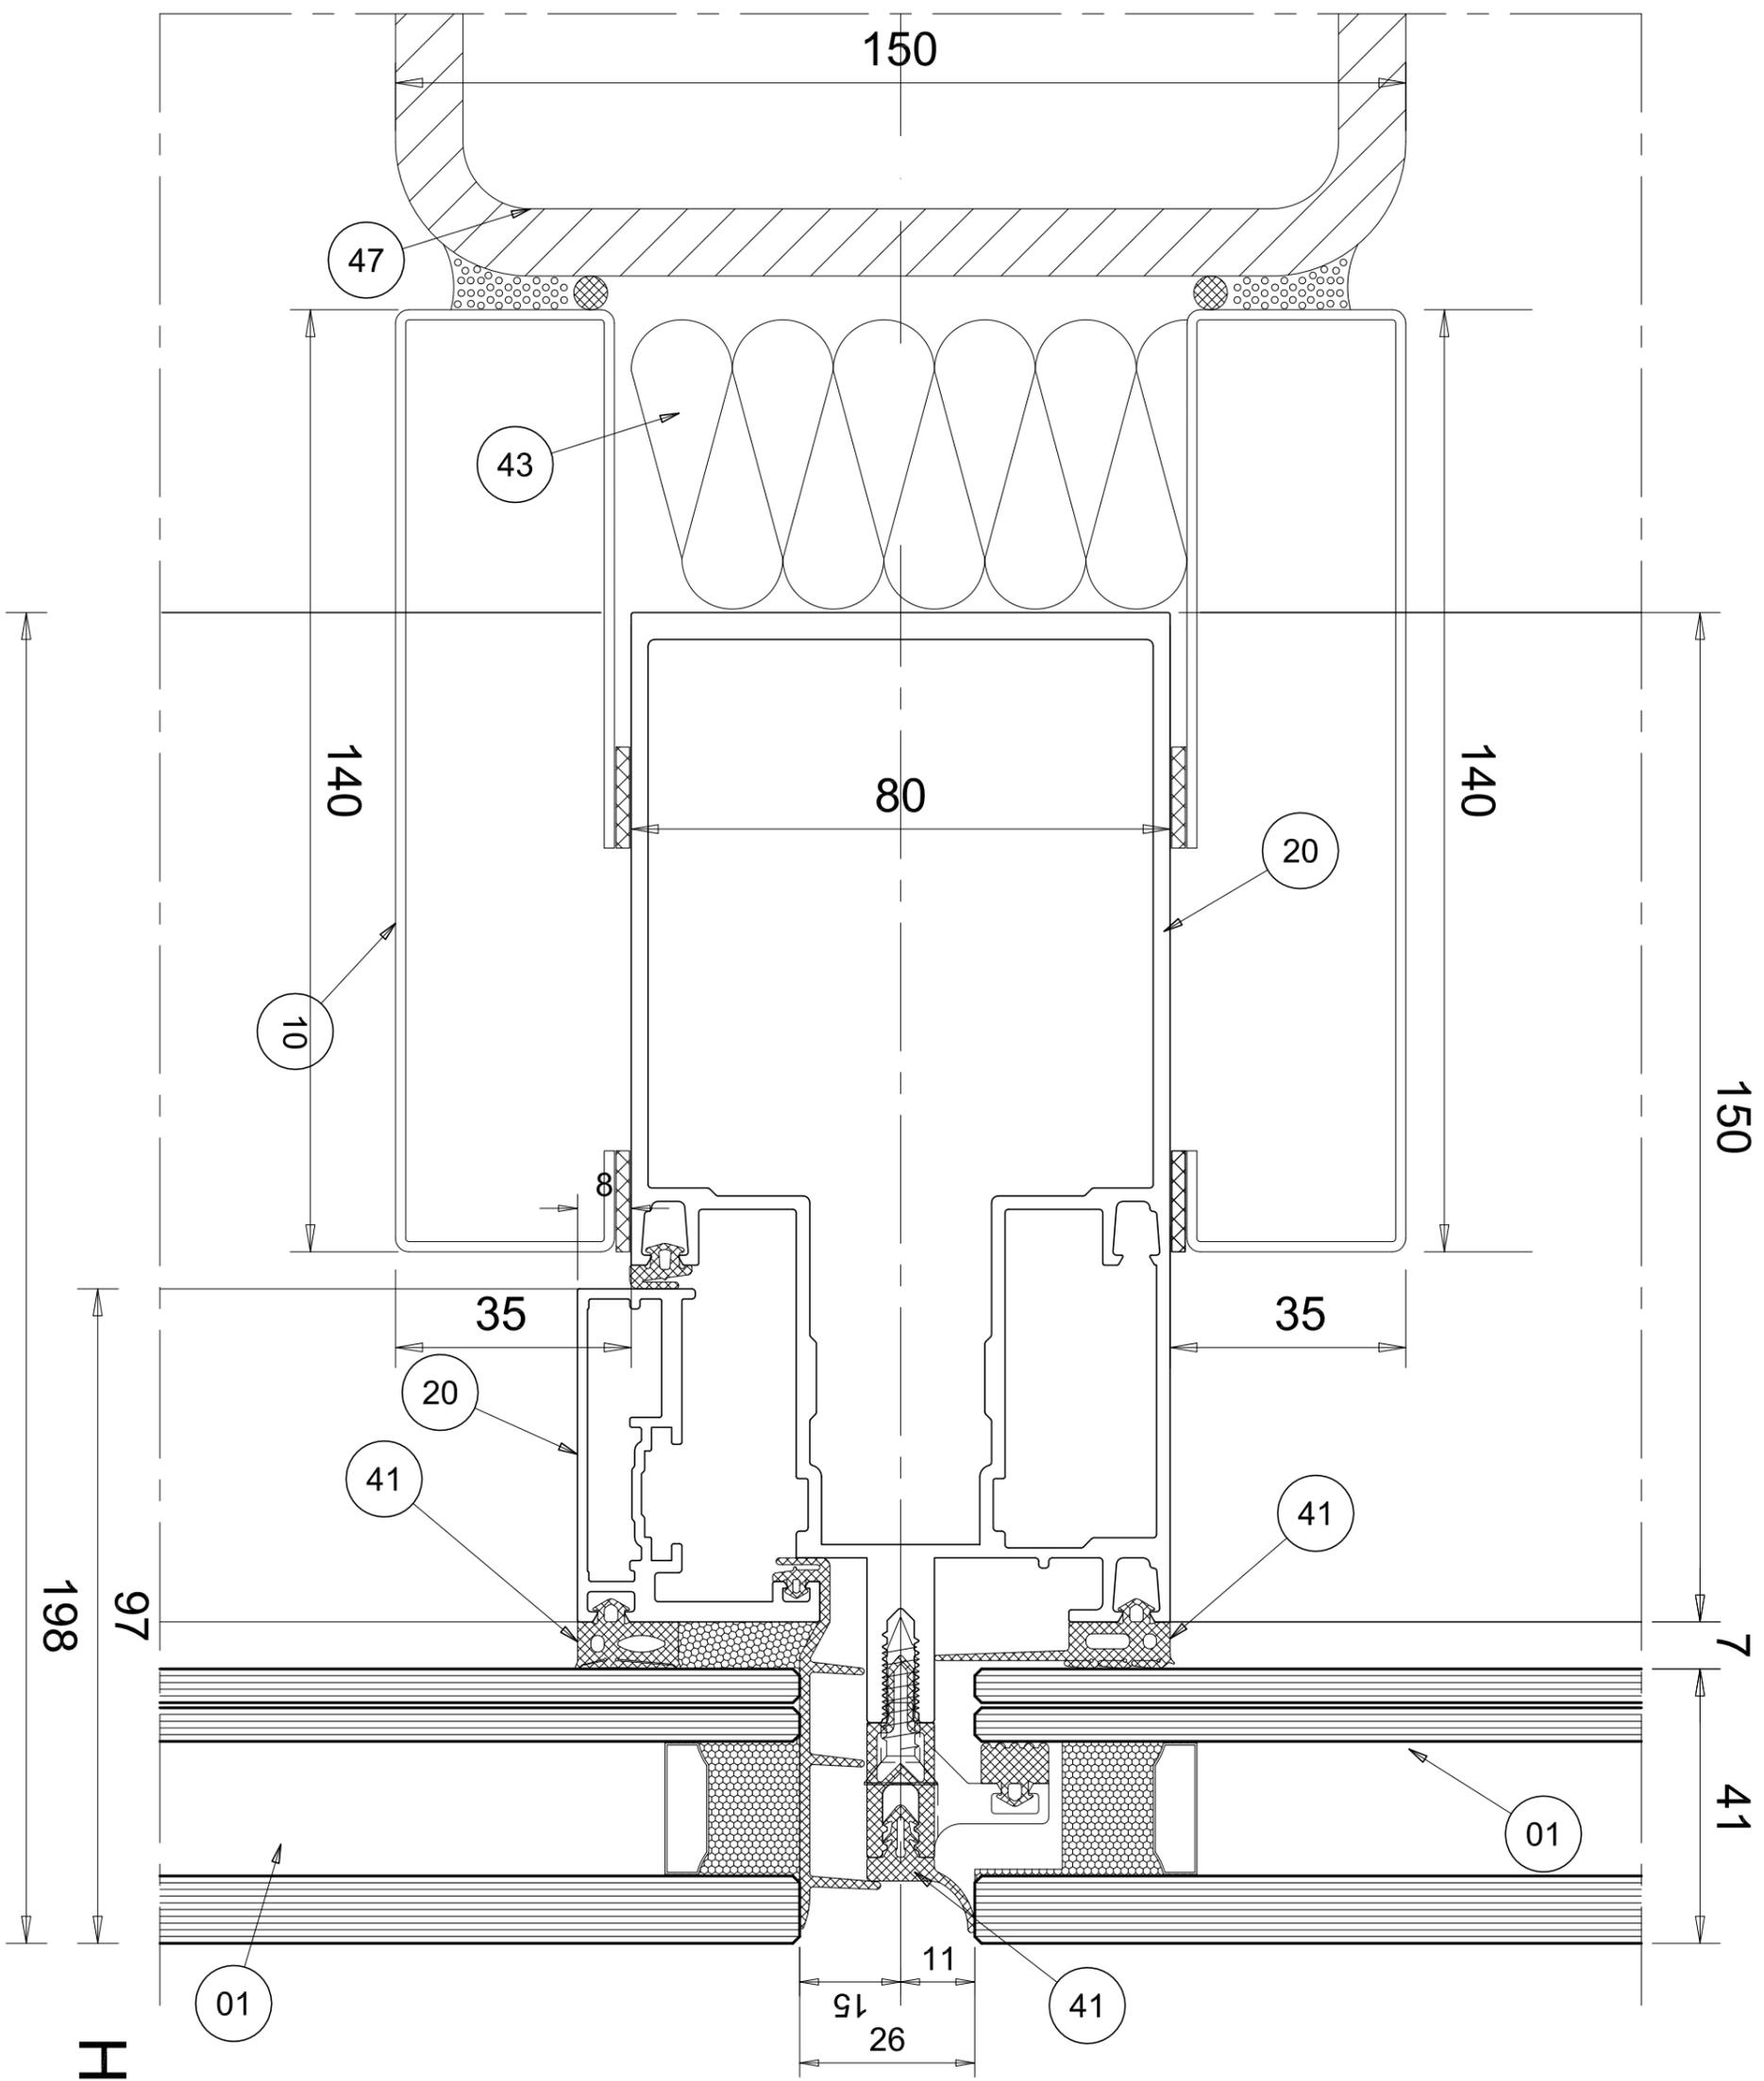

H-004A

LEGEND	
Nº	MATERIAL
01	DOUBLE GLAZING UNIT OUTER LITE: 10mm, TOUGHENED HST INNER LITE: 5&2 CLEAR FLOAT ACOUSTIC PVB INNER LITE: 5&2 CLEAR FLOAT ACOUSTIC PVB TOUGHENED HST
02	SINGLE GLASS CLEAR FLOAT 10mm th TOUGHENED HST DRINKLED COLOR BAL...
03	LAMINATED GLASS CLEAR FLOAT BR-4 TOUGHENED HST
10	ALUMINIUM SHEET 15/10 th
11	STAINLESS STEEL SHEET
12	GALVANIZED STEEL SHEET 15/10 th
13	GALVANIZED STEEL BRACKETS
20	ALUMINIUM EXTRUSIONS FOR C.W. PROFILES
30	STAINLESS STEEL SCREW
31	GALVANIZED STEEL SCREW
32	GALVANIZED STEEL BOLTS
33	EXPANSION BOLT
40	SILICONE DC 796 BLACK
41	EPDM EXTRUSION GASKET COLOR BLACK
42	SILICONE EXTRUSION GASKET COLOR BLACK
43	ROCK WOOL
44	1,5 mm thk ADHESIVE RUBBER MEMBRANE
45	RAISED FLOOR FINISH
46	CONCRETE SLAB
47	STEEL COLUMN
48	ALUMINIUM BORDER
49	STONE/CERAMIC FLOOR TILES
50	GYPSUM PLASTERBOARD FINISH
51	HALFEN SYSTEM SUPPORT
52	INTERNAL TEXTILE BLIND
53	ALUMINIUM SHEET 20/10 th

File : 926_Ae_07_107

Issue :
Main Project

Scale :
1:1

j.n.
926/09

Detail:

H-004A


Rev.:
-

Title :

The Curtain wall Glazing Facade - First floor
Section detail

Page:

16

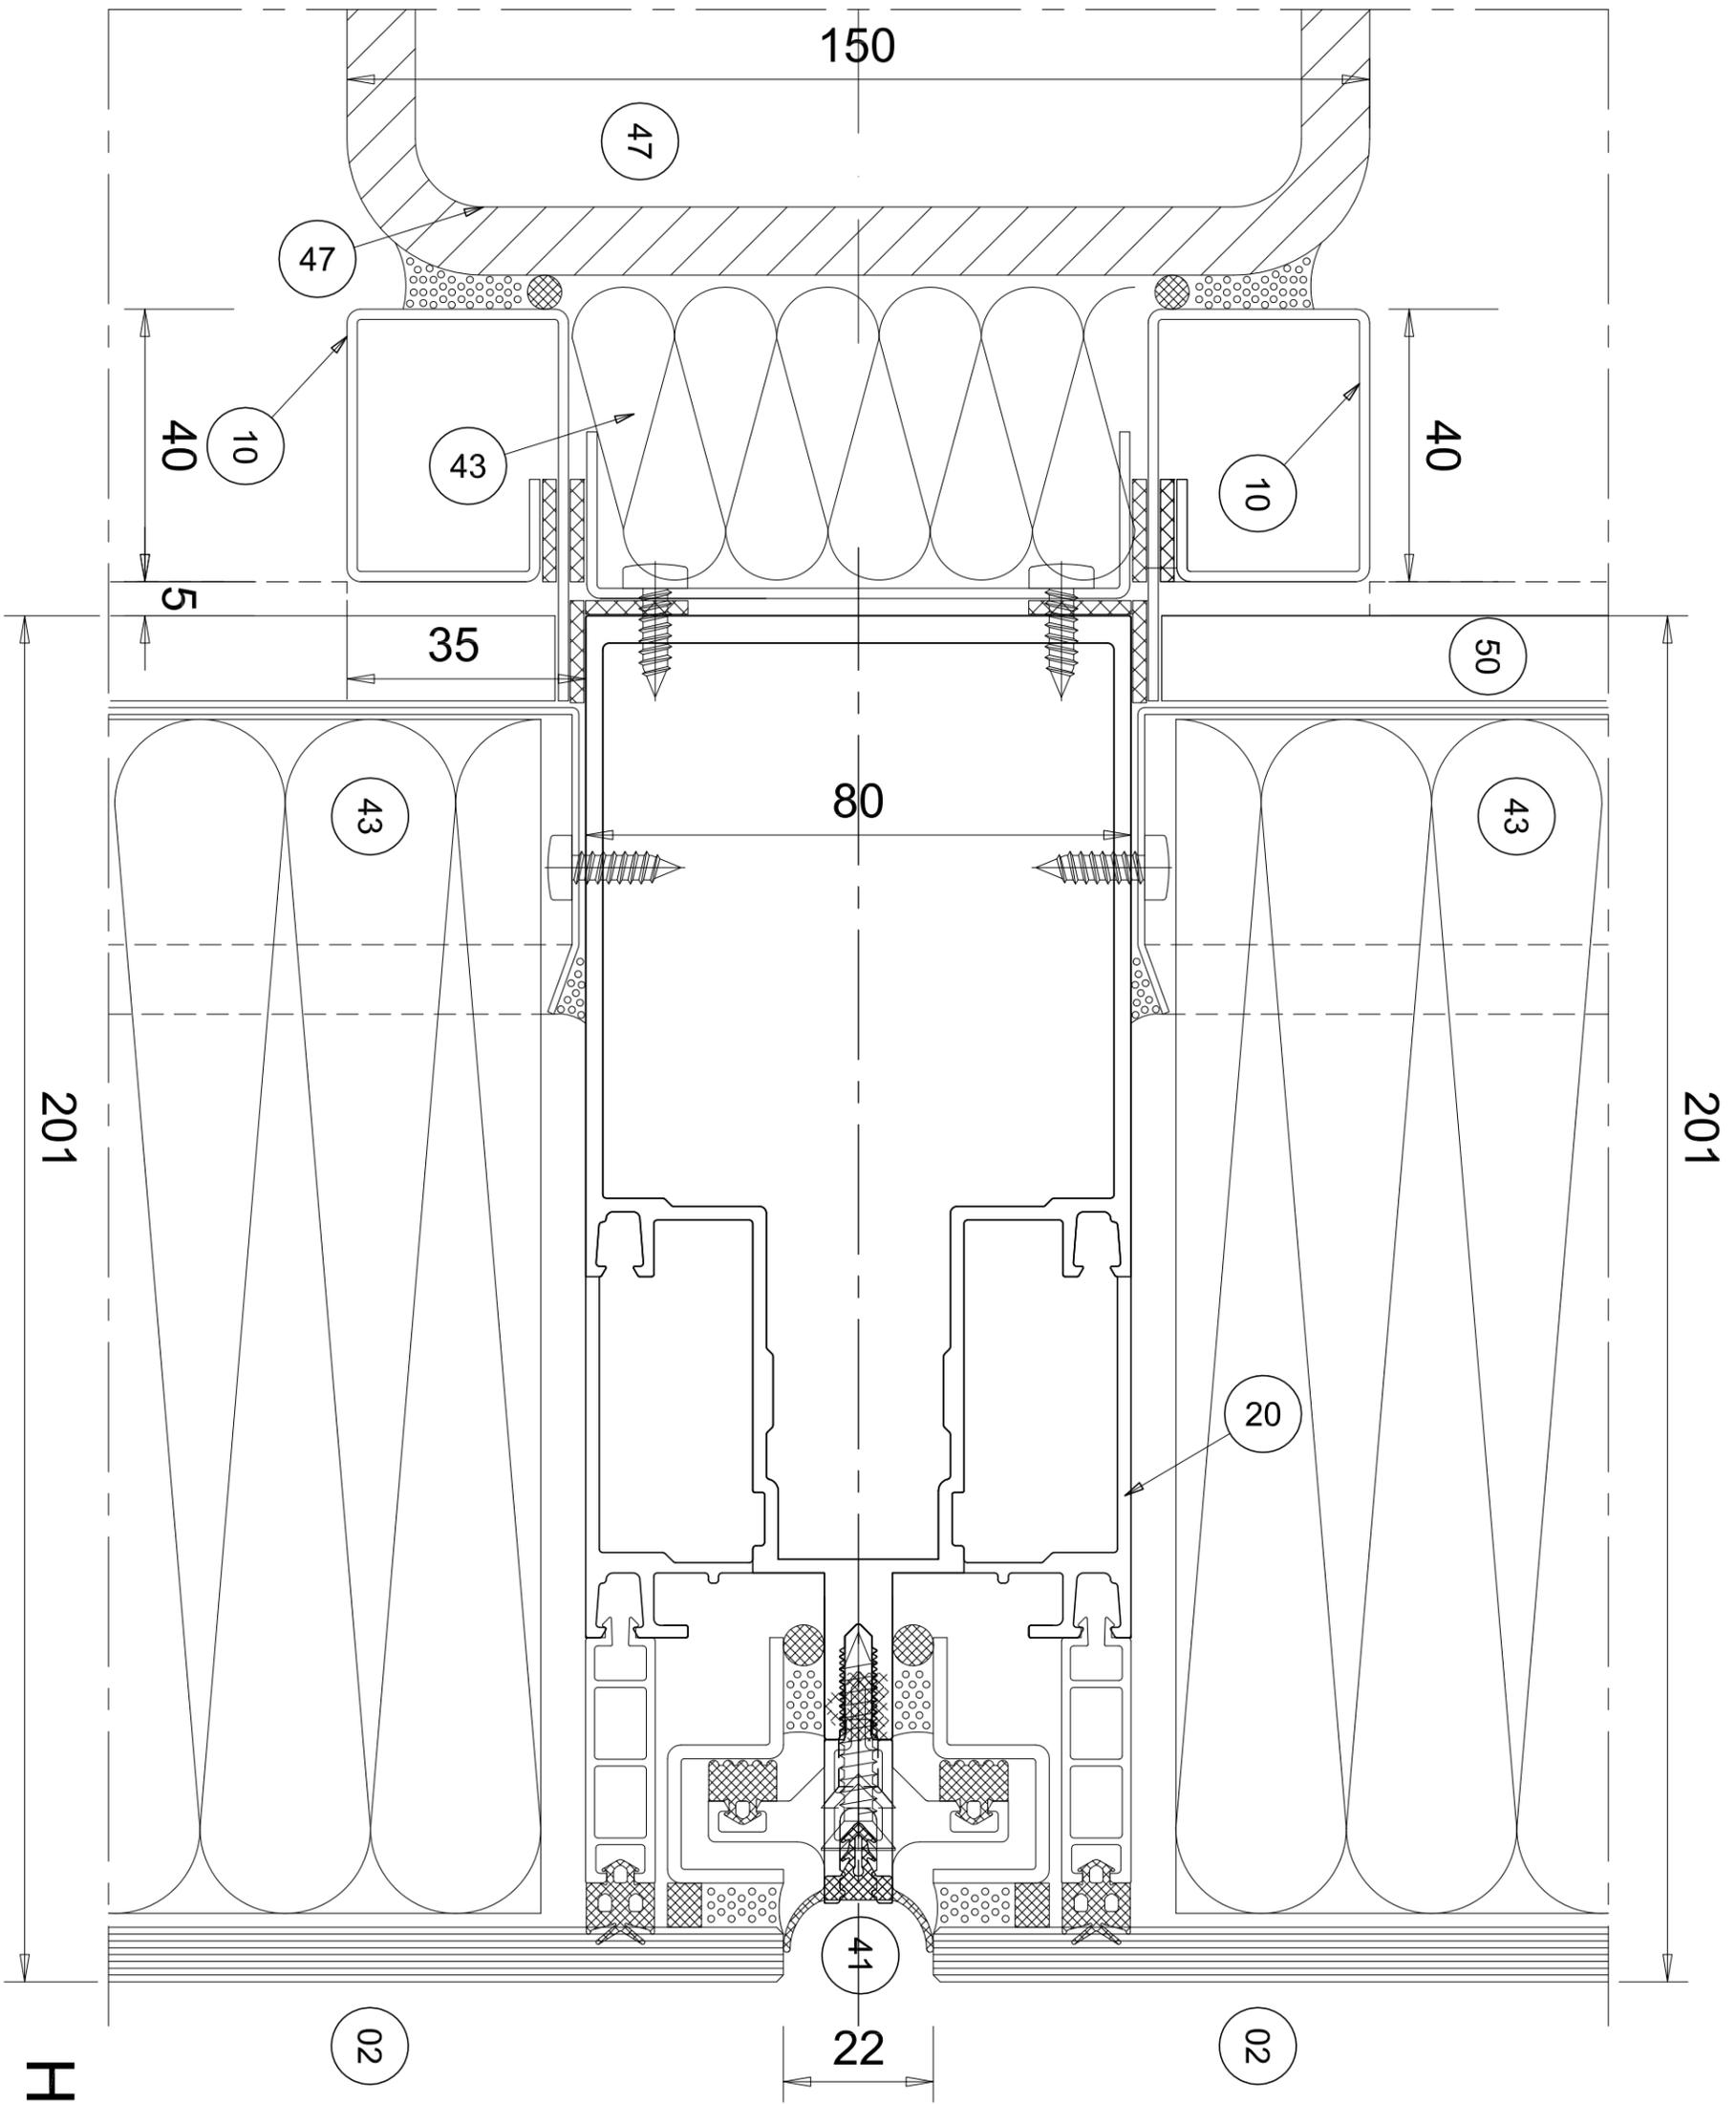


LEGEND	
Nº	MATERIAL
01	DOUBLE GLAZING UNIT OUTER LITE: 10mm, TOUGHENED HST INNER LITE: 5&2 CLEAR FLOAT ACOUSTIC PVB INNER LITE: 5&2 CLEAR FLOAT ACOUSTIC PVB TOUGHENED HST
02	SINGLE GLASS CLEAR FLOAT 10mm th TOUGHENED HST DRAINED COLOR BAL...
03	LAMINATED GLASS CLEAR FLOAT BR-4 TOUGHENED HST
10	ALUMINIUM SHEET 1&10 th
11	STAINLESS STEEL SHEET
12	GALVANIZED STEEL SHEET 1&10 th
13	GALVANIZED STEEL BRACKETS
20	ALUMINIUM EXTRUSIONS FOR C.W. PROFILES
30	STAINLESS STEEL SCREW
31	GALVANIZED STEEL SCREW
32	GALVANIZED STEEL BOLTS
33	EXPANSION BOLT
40	SILICONE DC 79& BLACK
41	EPDM EXTRUSION GASKET COLOR BLACK
42	SILICONE EXTRUSION GASKET COLOR BLACK
43	ROCK WOOL
44	1,5 mm thk ADHESIVE RUBBER MEMBRANE
45	RAISED FLOOR FINISH
46	CONCRETE SLAB
47	STEEL COLUMN
48	ALUMINIUM BORDER
49	STONE/CERAMIC FLOOR TILES
50	GYPSUM PLASTERBOARD FINISH
51	HALFEN SYSTEM SUPPORT
52	INTERNAL TEXTILE BLIND
53	ALUMINIUM SHEET 20/10 th

H-004B

File : 926_Ae_07_107		j.n.
Issue :	Scale :	926/09
Main Project	1:1	Rev.:
Detail:	H-004B	-

Title :
The Curtain wall Glazing Facade - First floor
Section detail


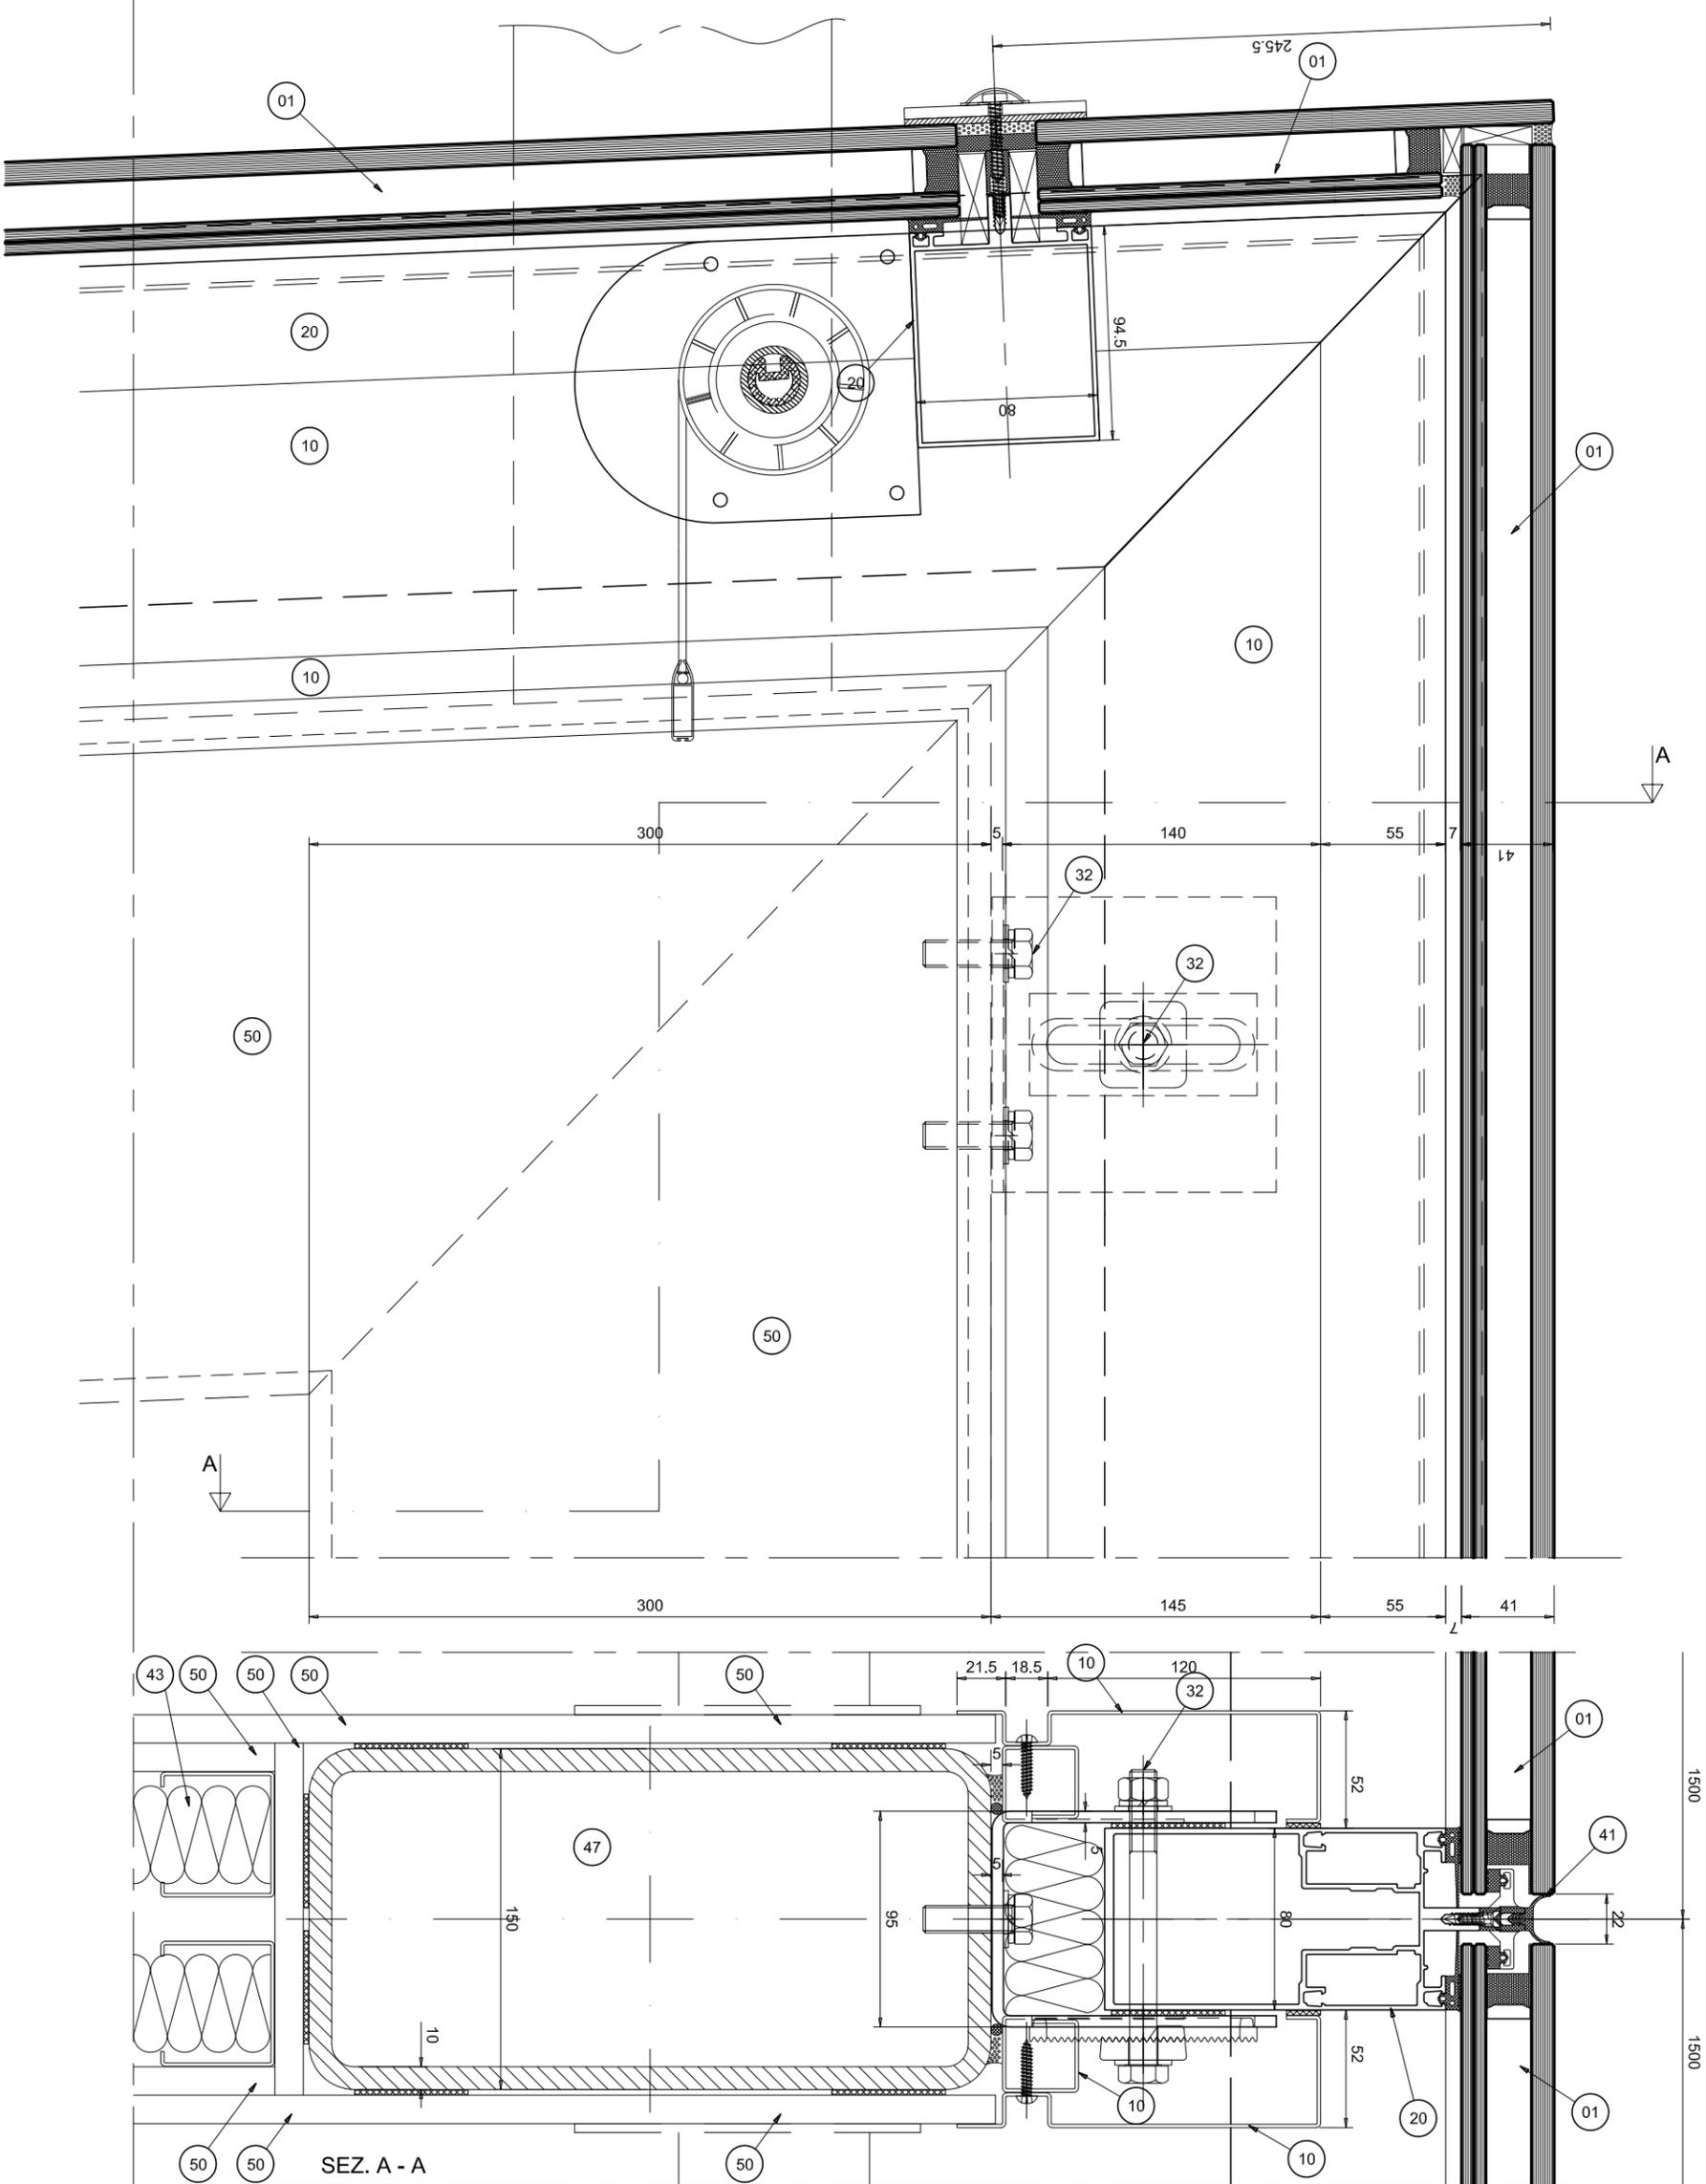


SEZ. A - A

LEGEND	
Nb	MATERIAL
01	DOUBLE GLAZING UNIT OUTER LITE: 10mm THK TOUNGHEED HST INNER LITE: 5x5 CLEAR FLOAT ACOUSTIC PVB INTER LITE: 5x5 CLEAR FLOAT ACOUSTIC PVB TOUGHEED HST EMERALD COLOR FAL...
02	SINGLE GLASS CLEAR FLOAT 10mm th TOUGHEED HST EMERALD COLOR FAL...
03	LAMINATED GLASS CLEAR FLOAT 9x4 TOUGHEED HST
10	ALUMINIUM SHEET 15/10 th
11	STAINLESS STEEL SHEET
12	GALVANIZED STEEL SHEET 15/10 th
13	GALVANIZED STEEL BRACKETS
20	ALUMINIUM EXTRUSIONS FOR C.W. PROFILES
30	STAINLESS STEEL SCREW
31	GALVANIZED STEEL SCREW
32	GALVANIZED STEEL BOLTS
33	EXPANSION BOLT
40	SILICONE DC 796 BLACK
41	EPDM EXTRUSION GASKET COLOR BLACK
42	SILICONE EXTRUSION GASKET COLOR BLACK
43	ROCK WOOL
44	1,5 mm thk ADHESIVE RUBBER MEMBRANE
45	RAISED FLOOR FINISH
46	CONCRETE SLAB
47	STEEL COLUMN
48	ALUMINIUM BORDER
49	STONE/CERAMIC FLOOR TILES
50	GYPSEUM PLASTERBOARD FINISH
51	HALTEN SYSTEM SUPPORT
52	INTERNAL TEXTILE BLIND
53	ALUMINIUM SHEET 20/10 th

File : 926_Ae_07_107		
Issue :	Scale :	j.n.
Main Project	1:3	926/09
Detail:	V-007A	Rev.:
		-

Title :
The Curtain wall Glazing Facade - First floor
 Section detail - office wall

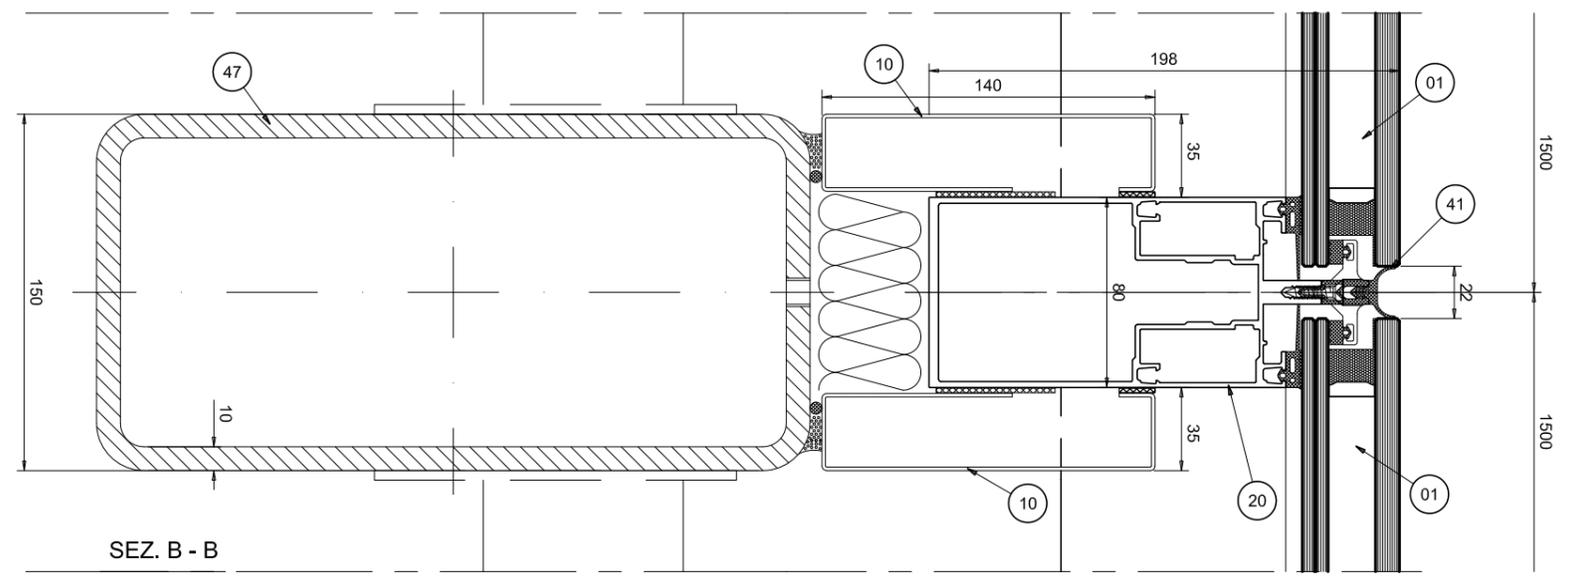
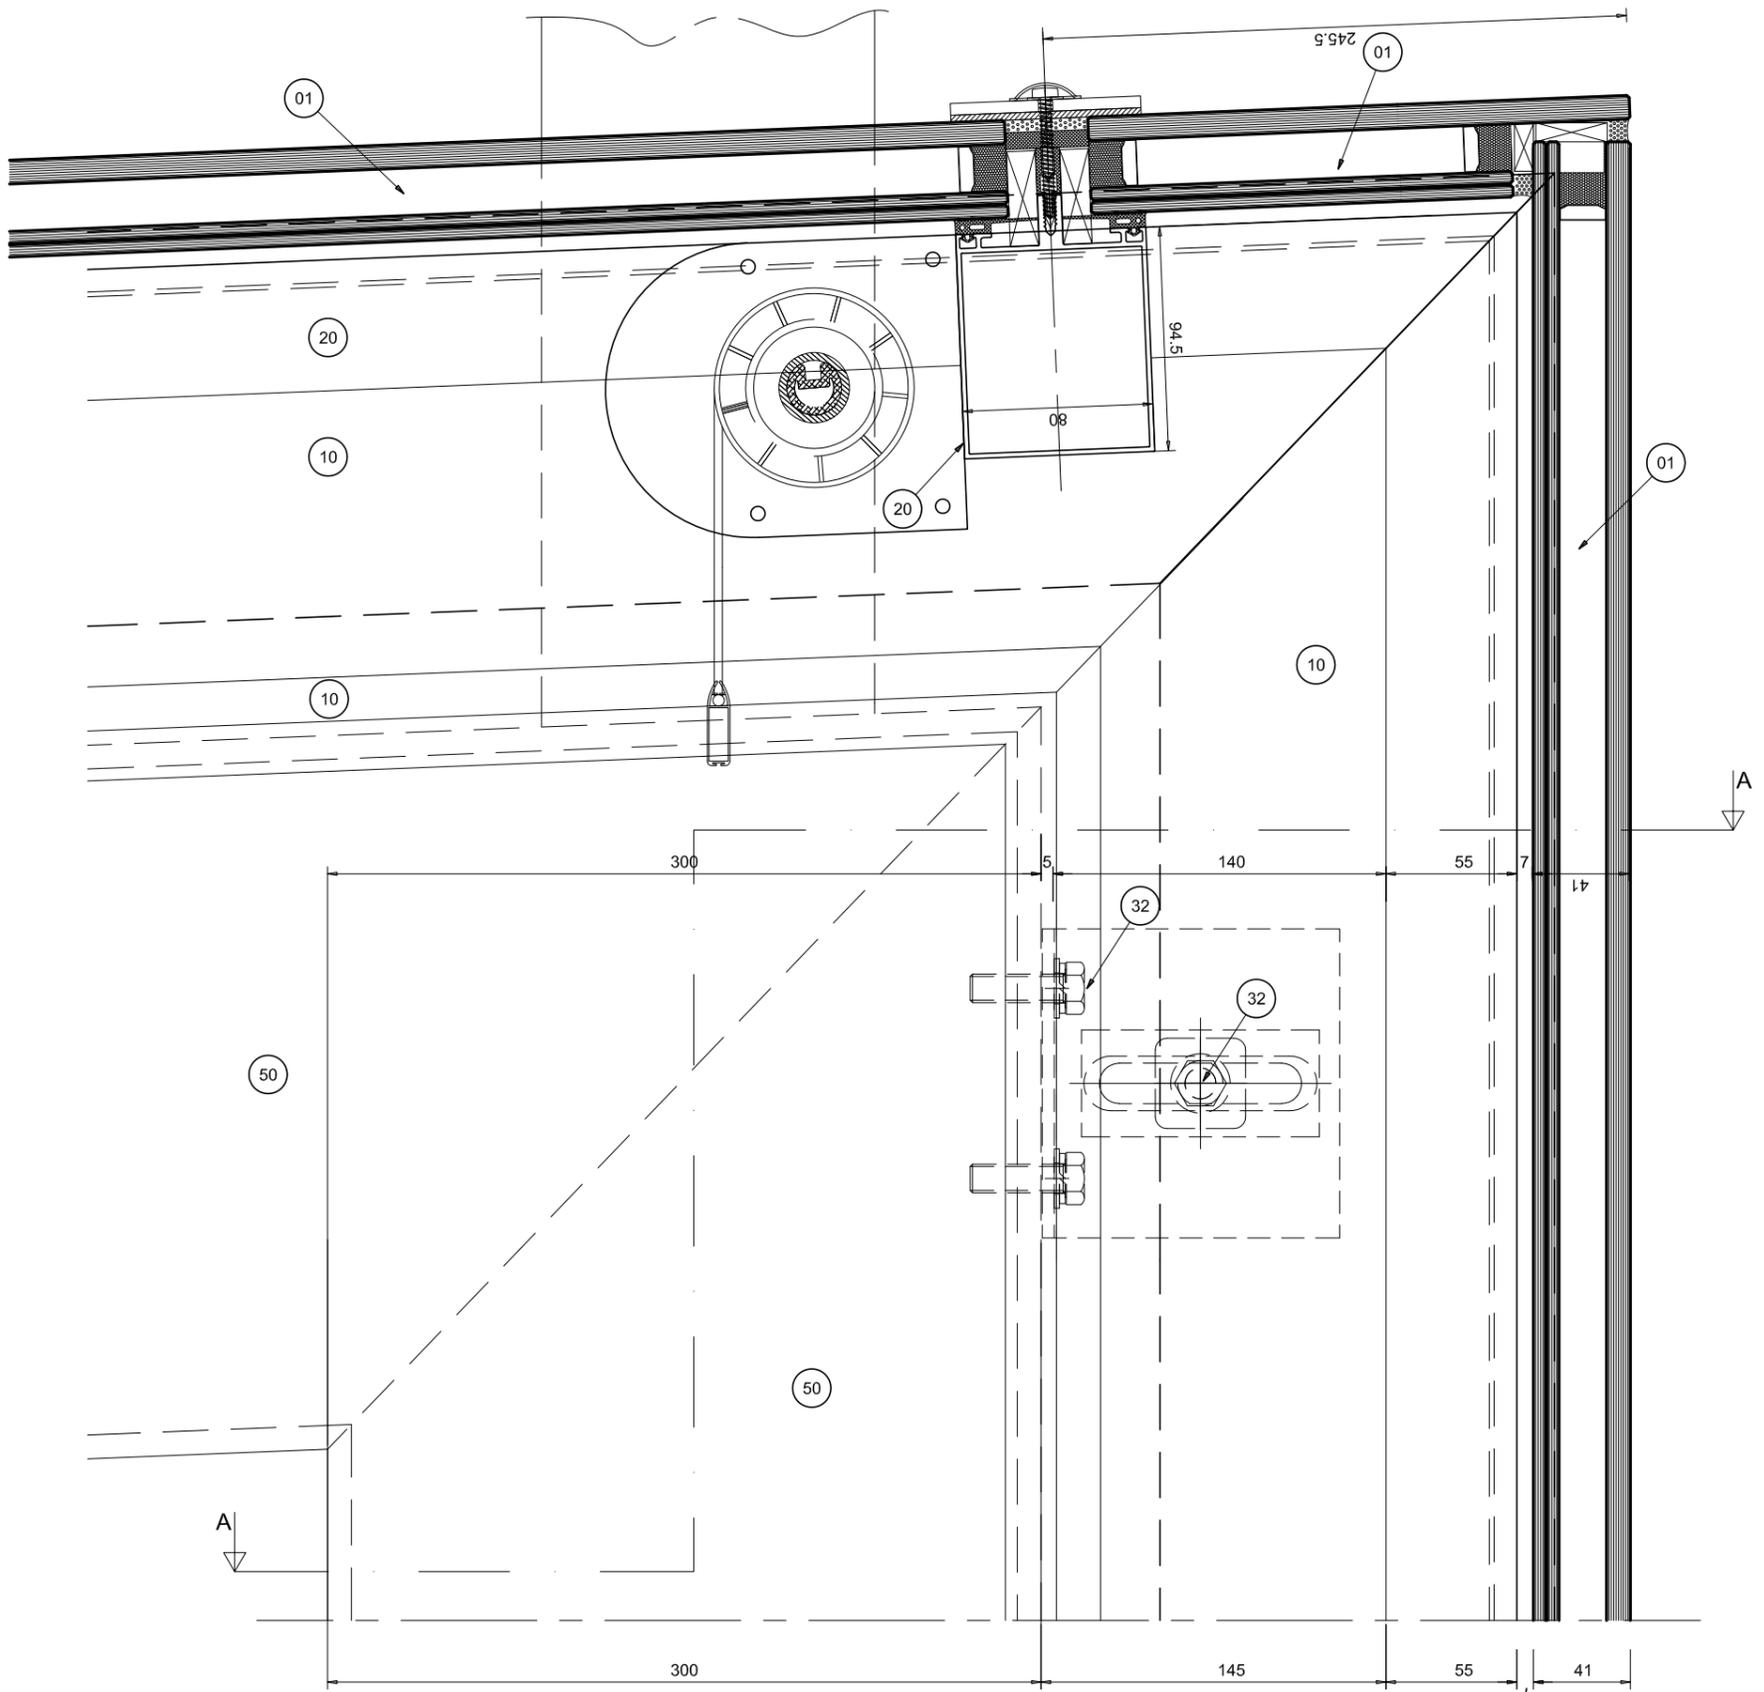


SEZ. B - B

LEGEND	
Nb	MATERIAL
01	DOUBLE GLAZING UNIT OUTER LITE: 10mm thk TONED HST INNER LITE: 10mm thk TONED HST INNER LITE: 5x2 CLEAR FLOAT ACOUSTIC PVB SINGLE GLASS CLEAR FLOAT 10mm th TOUGHENED HST EMERALD COLOR BAL...
02	LAMINATED GLASS CLEAR FLOAT 8x4 TOUGHENED HST
03	ALUMINIUM SHEET 15/10 th
10	STAINLESS STEEL SHEET
11	GALVANIZED STEEL SHEET 15/10 th
12	ALUMINIUM EXTRUSIONS FOR C.W. PROFILES
13	STAINLESS STEEL SCREW
20	GALVANIZED STEEL SCREW
30	EXPANSION BOLT
31	EXPANSION BOLT
32	SILICONE DC 796 BLACK
33	EPDM EXTRUSION GASKET COLOR BLACK
40	SILICONE EXTRUSION GASKET COLOR BLACK
41	ROCK WOOL
42	1,5 mm thk ADHESIVE RUBBER MEMBRANE
43	RAISED FLOOR FINISH
44	CONCRETE SLAB
45	STEEL COLUMN
46	ALUMINIUM BORDER
47	STONE/CERAMIC FLOOR TILES
48	GYPSUM PLASTERBOARD FINISH
49	HALTEN SYSTEM SUPPORT
50	INTERNAL TEXTILE BLIND
51	ALUMINIUM SHEET 20/10 th
52	
53	

File : 926_Ae_07_107		
Issue :	Scale :	j.n.
Main Project	1:3	926/09
Detail:	V-007B	Rev.:
		-

Title :
The Curtain wall Glazing Facade - First floor
 Section detail - steel column

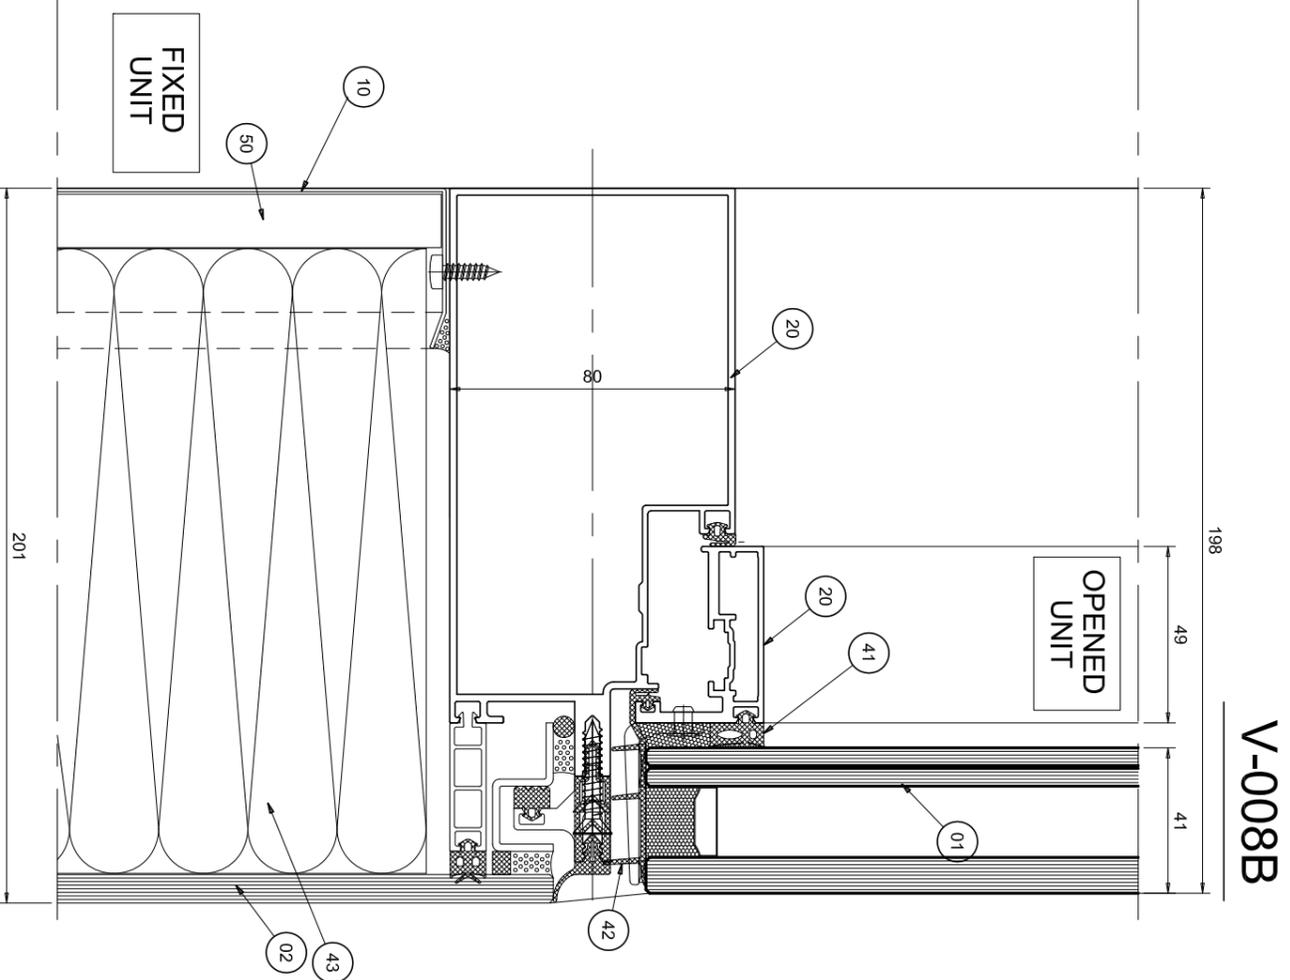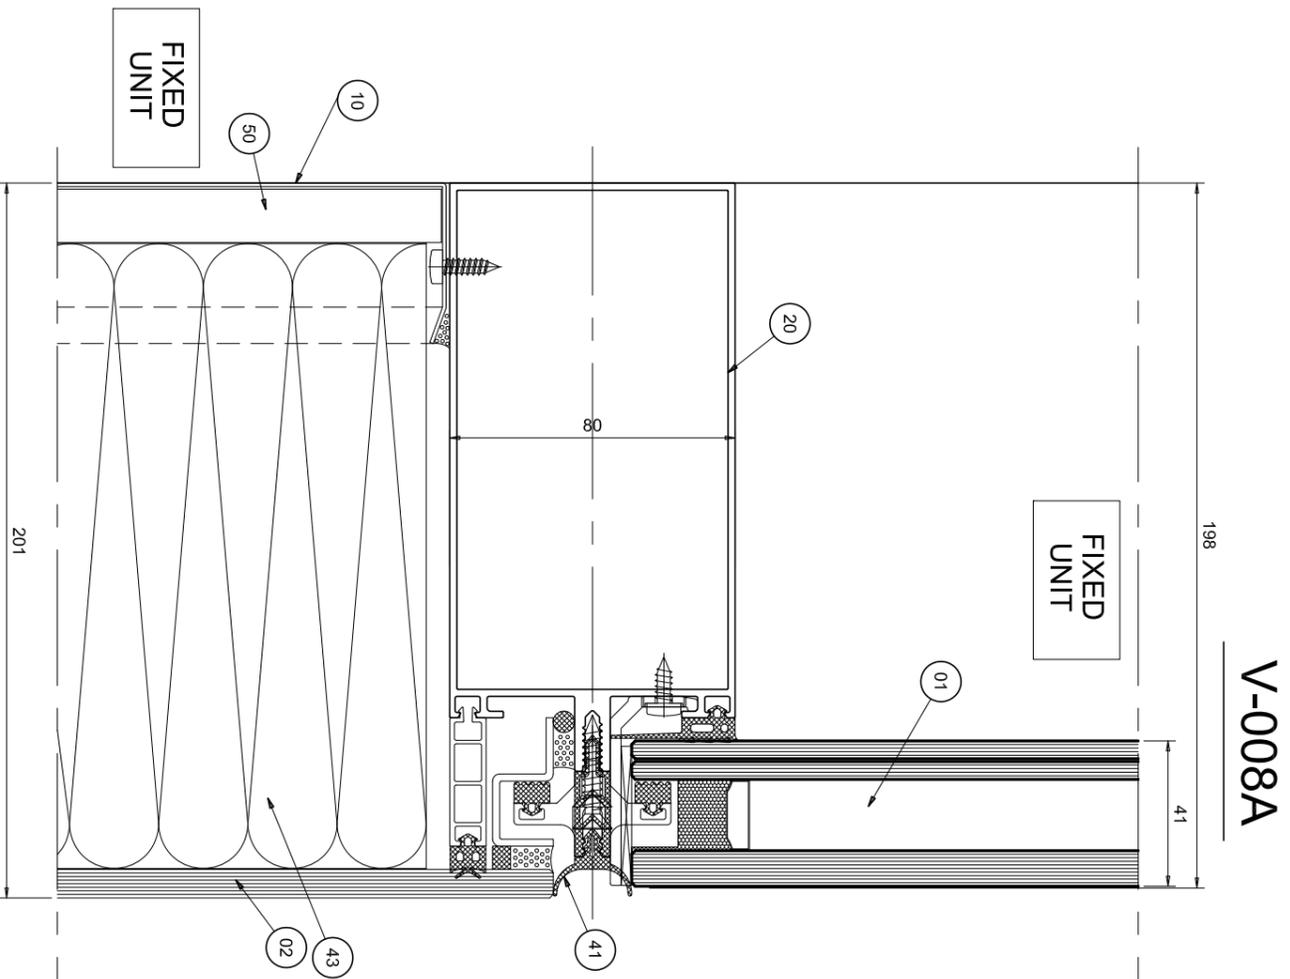


10 INTERNAL OFFICE FINISH (BALUSTRADE ZONE): ALUMINIUM PERFORATE AND PAINTED

LEGEND	
No	MATERIAL
01	DOUBLE GLAZING UNIT DOUBLE LITE 10mm, TOUGHENED HST INNER LITE: 55,2 CLEAR FLOAT ACOUSTIC PVB SINGLE GLASS CLEAR FLOAT 10mm th
02	TOUGHENED HST TOUGHENED HST DIMENSIONED COLOR BAL...
03	LAMINATED GLASS CLEAR FLOAT BR-4 TOUGHENED HST
10	ALUMINIUM SHEET 15/10 th
11	STAINLESS STEEL SHEET
12	GALVANIZED STEEL SHEET 15/10 th
13	GALVANIZED STEEL BRACKETS
20	ALUMINIUM EXTRUSIONS FOR C.W. PROFILES
30	STAINLESS STEEL SCREW
31	GALVANIZED STEEL SCREW
32	GALVANIZED STEEL BOLTS
33	EXPANSION BOLT
40	SILICONE DC 796 BLACK
41	EPDM EXTRUSION GASKET COLOR BLACK
42	SILICONE EXTRUSION GASKET COLOR BLACK
43	ROCK WOOL
44	1,5 mm thk ADHESIVE RUBBER MEMBRANE
45	RAISED FLOOR FINISH
46	CONCRETE SLAB
47	STEEL COLUMN
48	ALUMINIUM BORDER
49	STONE/CERAMIC FLOOR TILES
50	GYPSUM PLASTERBOARD FINISH
51	HALFEN SYSTEM SUPPORT
52	INTERNAL TEXTILE BLIND
53	ALUMINIUM SHEET 20/10 th

File : 926_Ae_07_107	j.n. 926/09
Issue : Main Project	Scale : 1:2
Detail: V-008	Rev.: -

Title : The Curtain wall Glazing Facade - First floor
Ssection detail

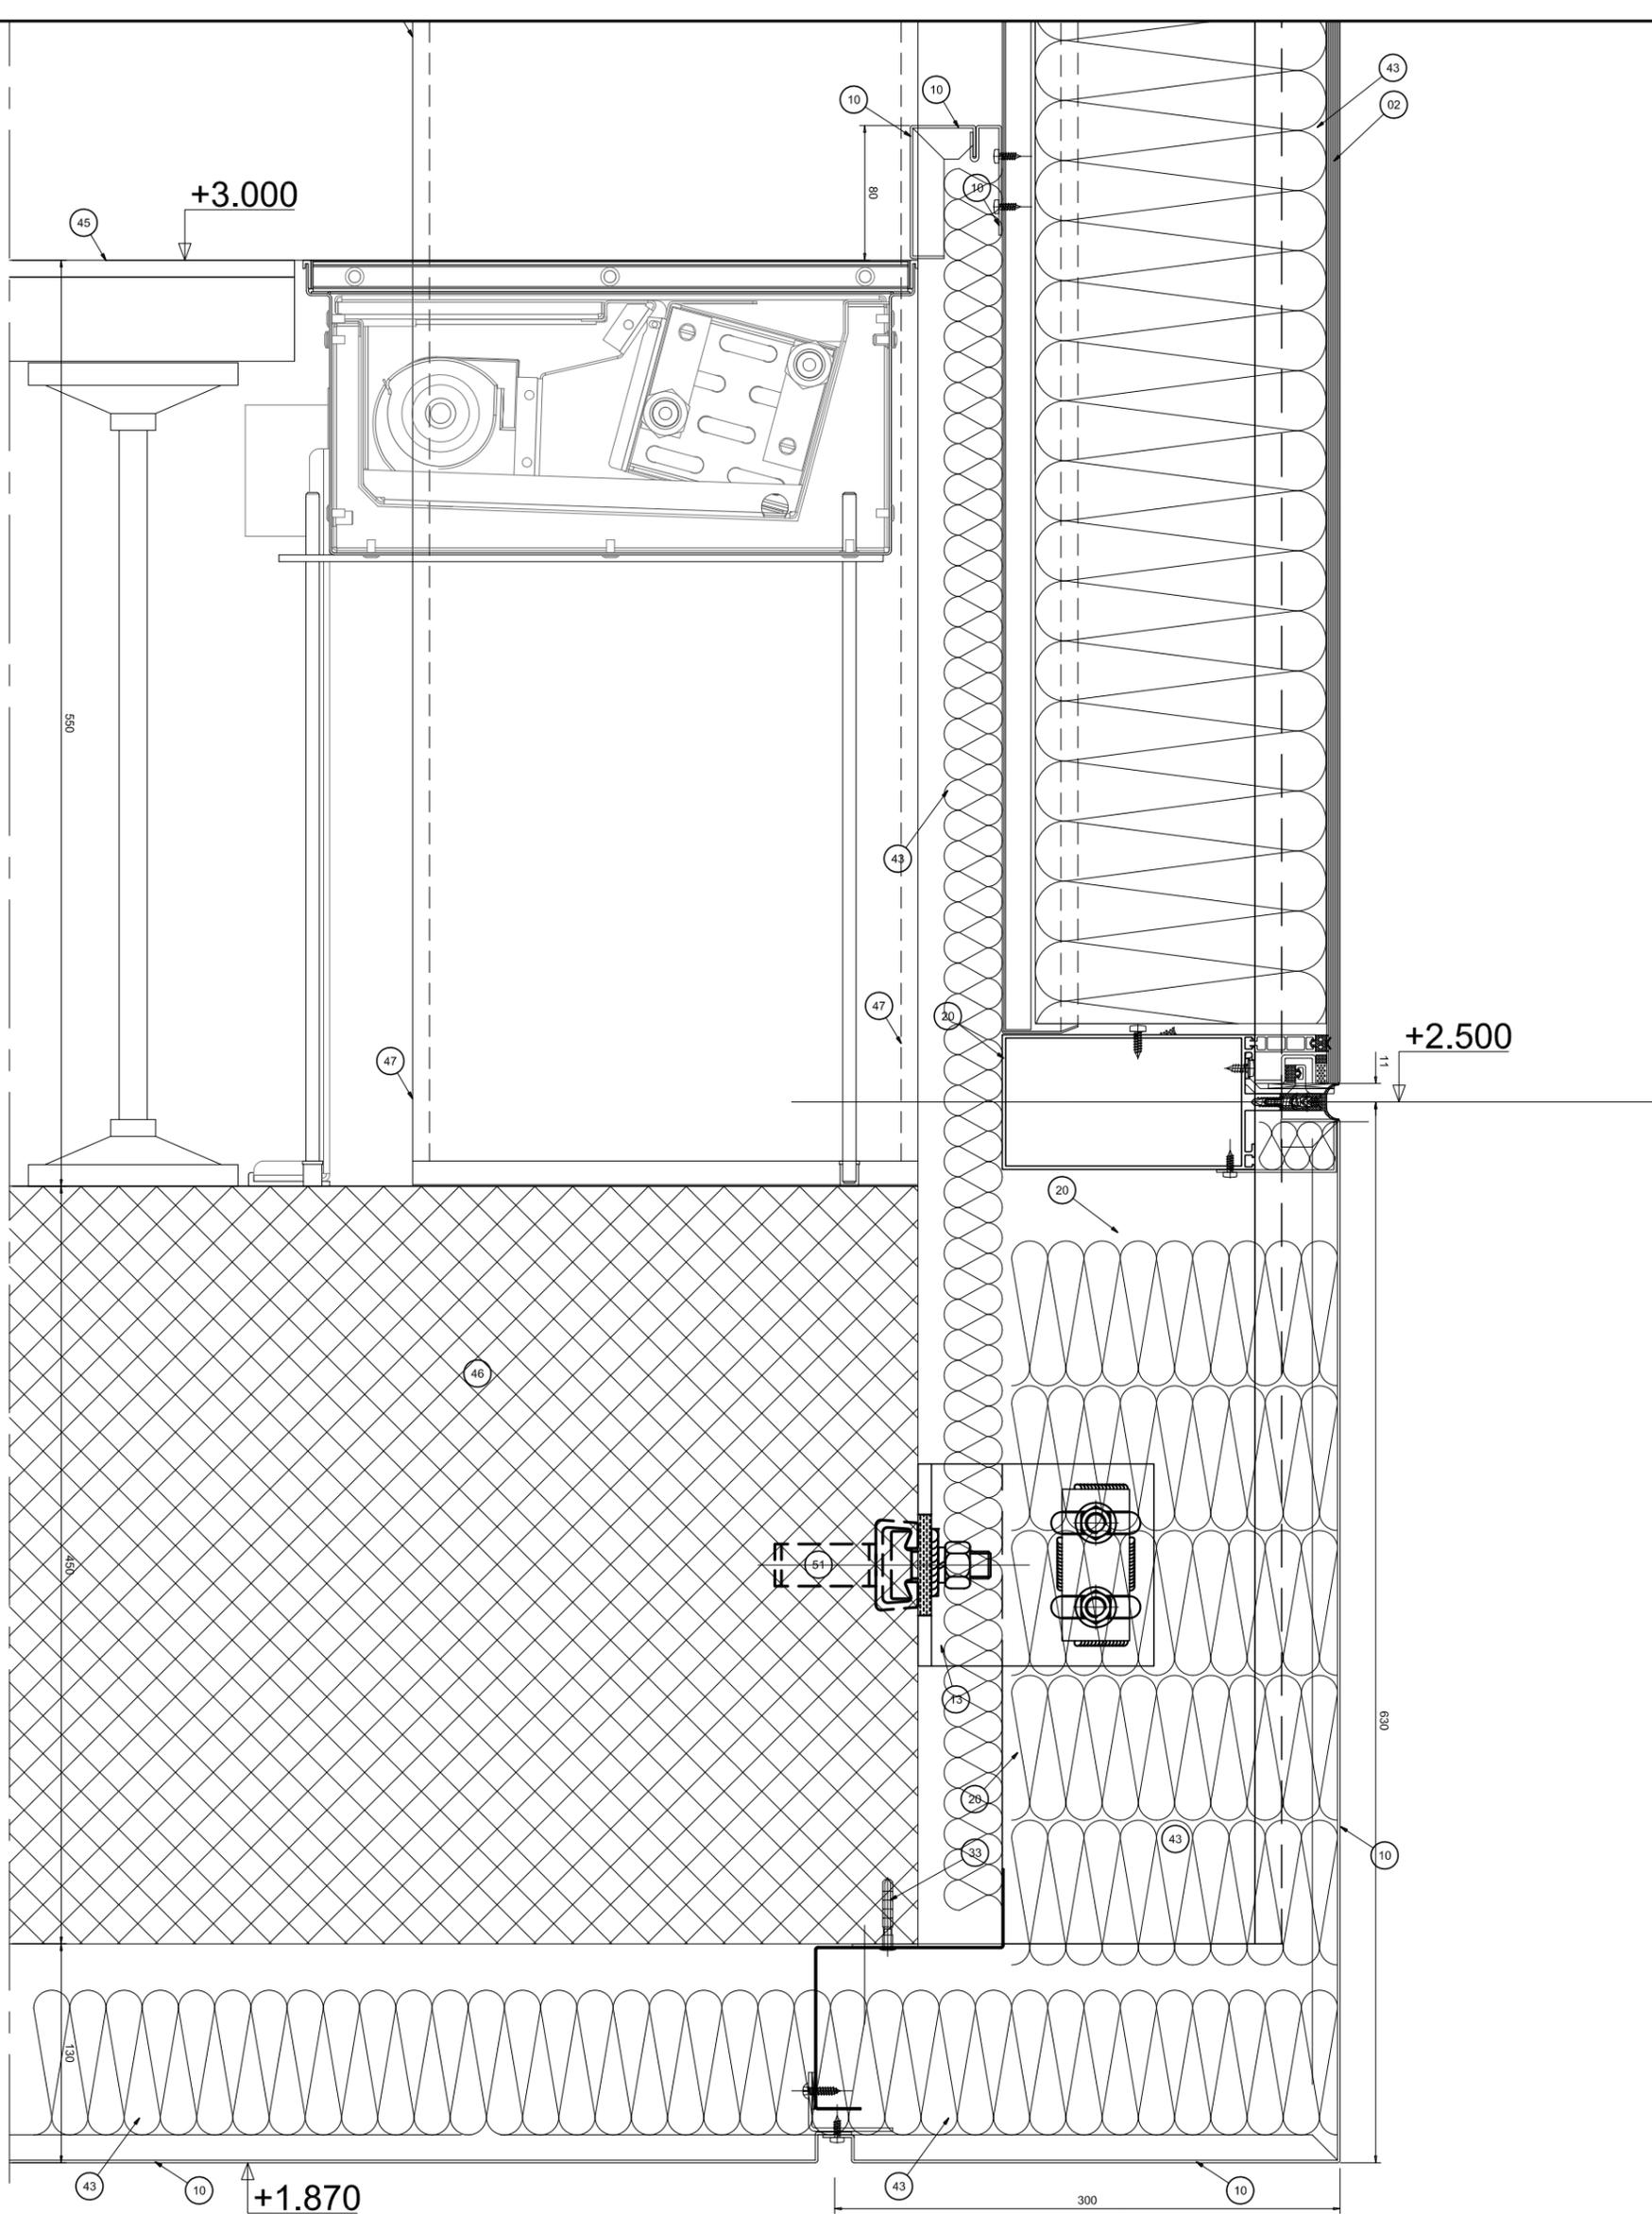

LEGEND	
№	MATERIAL
01	DOUBLE GLAZING UNIT OUTER LITE: 10mm, TOUGHENED HST SPACE 20mm, ARCON 80% WE INNER LITE: 55,2 CLEAR FLOAT ACOUSTIC PVB TOUGHENED HST
02	SINGLE GLASS CLEAR FLOAT 10mm th TOUGHENED HST ENAMELLED COLOR RAL...
03	LAMINATED GLASS CLEAR FLOAT BR4 TOUGHENED HST
10	ALUMINIUM SHEET 15/10 th
11	STAINLESS STEEL SHEET
12	GALVANIZED STEEL SHEET 15/10 th
13	GALVANIZED STEEL BRACKETS
20	ALUMINIUM EXTRUSIONS FOR C.W. PROFILES
30	STAINLESS STEEL SCREW
31	GALVANIZED STEEL SCREW
32	GALVANIZED STEEL BOLTS
33	EXPANSION BOLT
40	SILICONE DC 790 BLACK
41	EPDM EXTRUSION GASKET COLOR BLACK
42	SILICONE EXTRUSION GASKET COLOR BLACK
43	ROCK WOOL
44	1,5 mm th. ADHESIVE RUBBER MEMBRANE
45	RAISED FLOOR FINISH
46	CONCRETE SLAB
47	STEEL COLUMN
48	ALUMINIUM BORDER
49	STONE/CERAMIC FLOOR TILES
50	GYPSUM PLASTERBOARD FINISH
51	HALTERN SYSTEM SUPPORT
52	INTERNAL TEXTILE BLIND
53	ALUMINIUM SHEET 20/10 th

File : 926_Ae_07_107

Issue :
Main Project

Scale :
1:4

j.n.
926/09

Detail: v-009


Rev.:
-

Title :

The Curtain wall Glazing Facade - First floor
Section detail

Page:

21

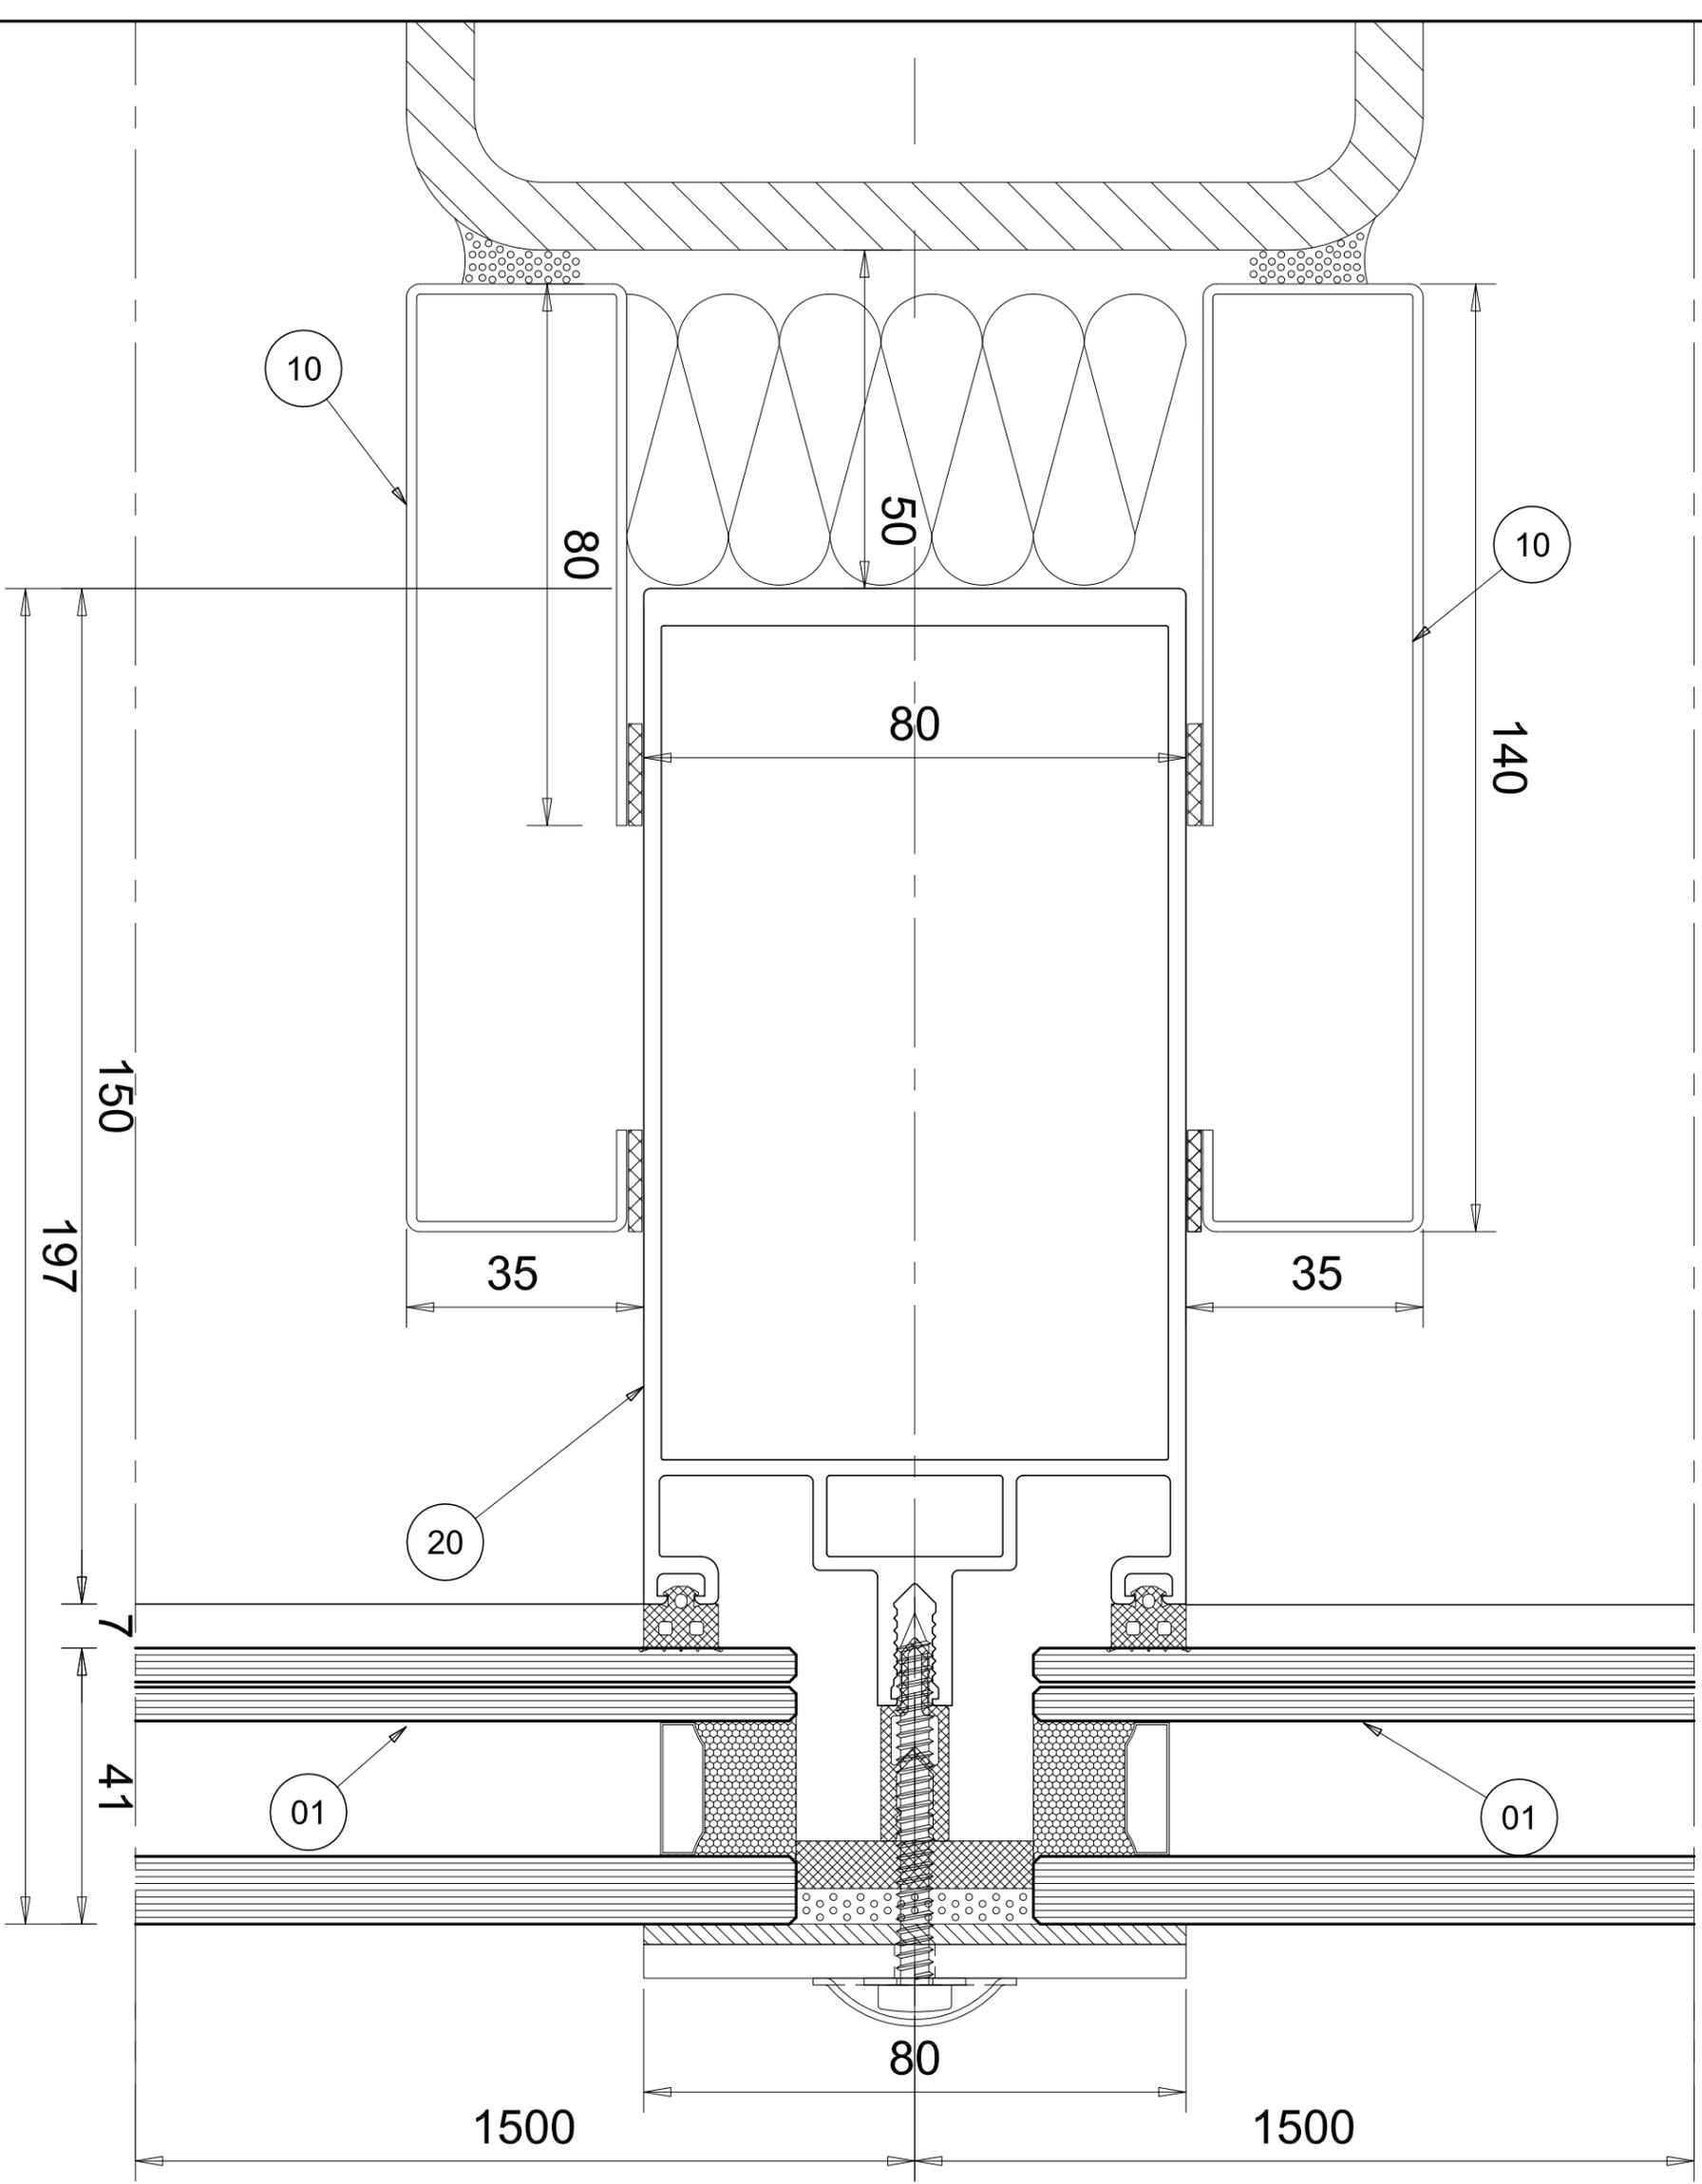

LEGEND	
No	MATERIAL
01	DOUBLE GLAZING UNIT OUTER LITE: 10mm, TOUGHENED HST INNER LITE: 5&2 CLEAR FLOAT ACOUSTIC PVB INTER LITE: 5&2 CLEAR FLOAT ACOUSTIC PVB TOUGHENED HST
02	SINGLE GLASS CLEAR FLOAT 10mm th TOUGHENED HST EMBEDDED COLOR BAL...
03	LAMINATED GLASS CLEAR FLOAT BR-4 TOUGHENED HST
10	ALUMINIUM SHEET 1&10 th
11	STAINLESS STEEL SHEET
12	GALVANIZED STEEL SHEET 1&10 th
13	GALVANIZED STEEL BRACKETS
20	ALUMINIUM EXTRUSIONS FOR C.W. PROFILES
30	STAINLESS STEEL SCREW
31	GALVANIZED STEEL SCREW
32	GALVANIZED STEEL BOLTS
33	EXPANSION BOLT
40	SILICONE DC 79& BLACK
41	EPDM EXTRUSION GASKET COLOR BLACK
42	SILICONE EXTRUSION GASKET COLOR BLACK
43	ROCK WOOL
44	1,5 mm th ADHESIVE RUBBER MEMBRANE
45	RAISED FLOOR FINISH
46	CONCRETE SLAB
47	STEEL COLUMN
48	ALUMINIUM BORDER
49	STONE/CERAMIC FLOOR TILES
50	GYPSUM PLASTERBOARD FINISH
51	HALFEN SYSTEM SUPPORT
52	INTERNAL TEXTILE BLIND
53	ALUMINIUM SHEET 20/10 th

File : 926_Ae_07_107

Issue : Main Project


Scale : 1:1

j.n. 926/09

Detail: V-010

Rev.: -

Title : **The Curtain wall Glazing Facade - First floor roof**
The skylight Section detail

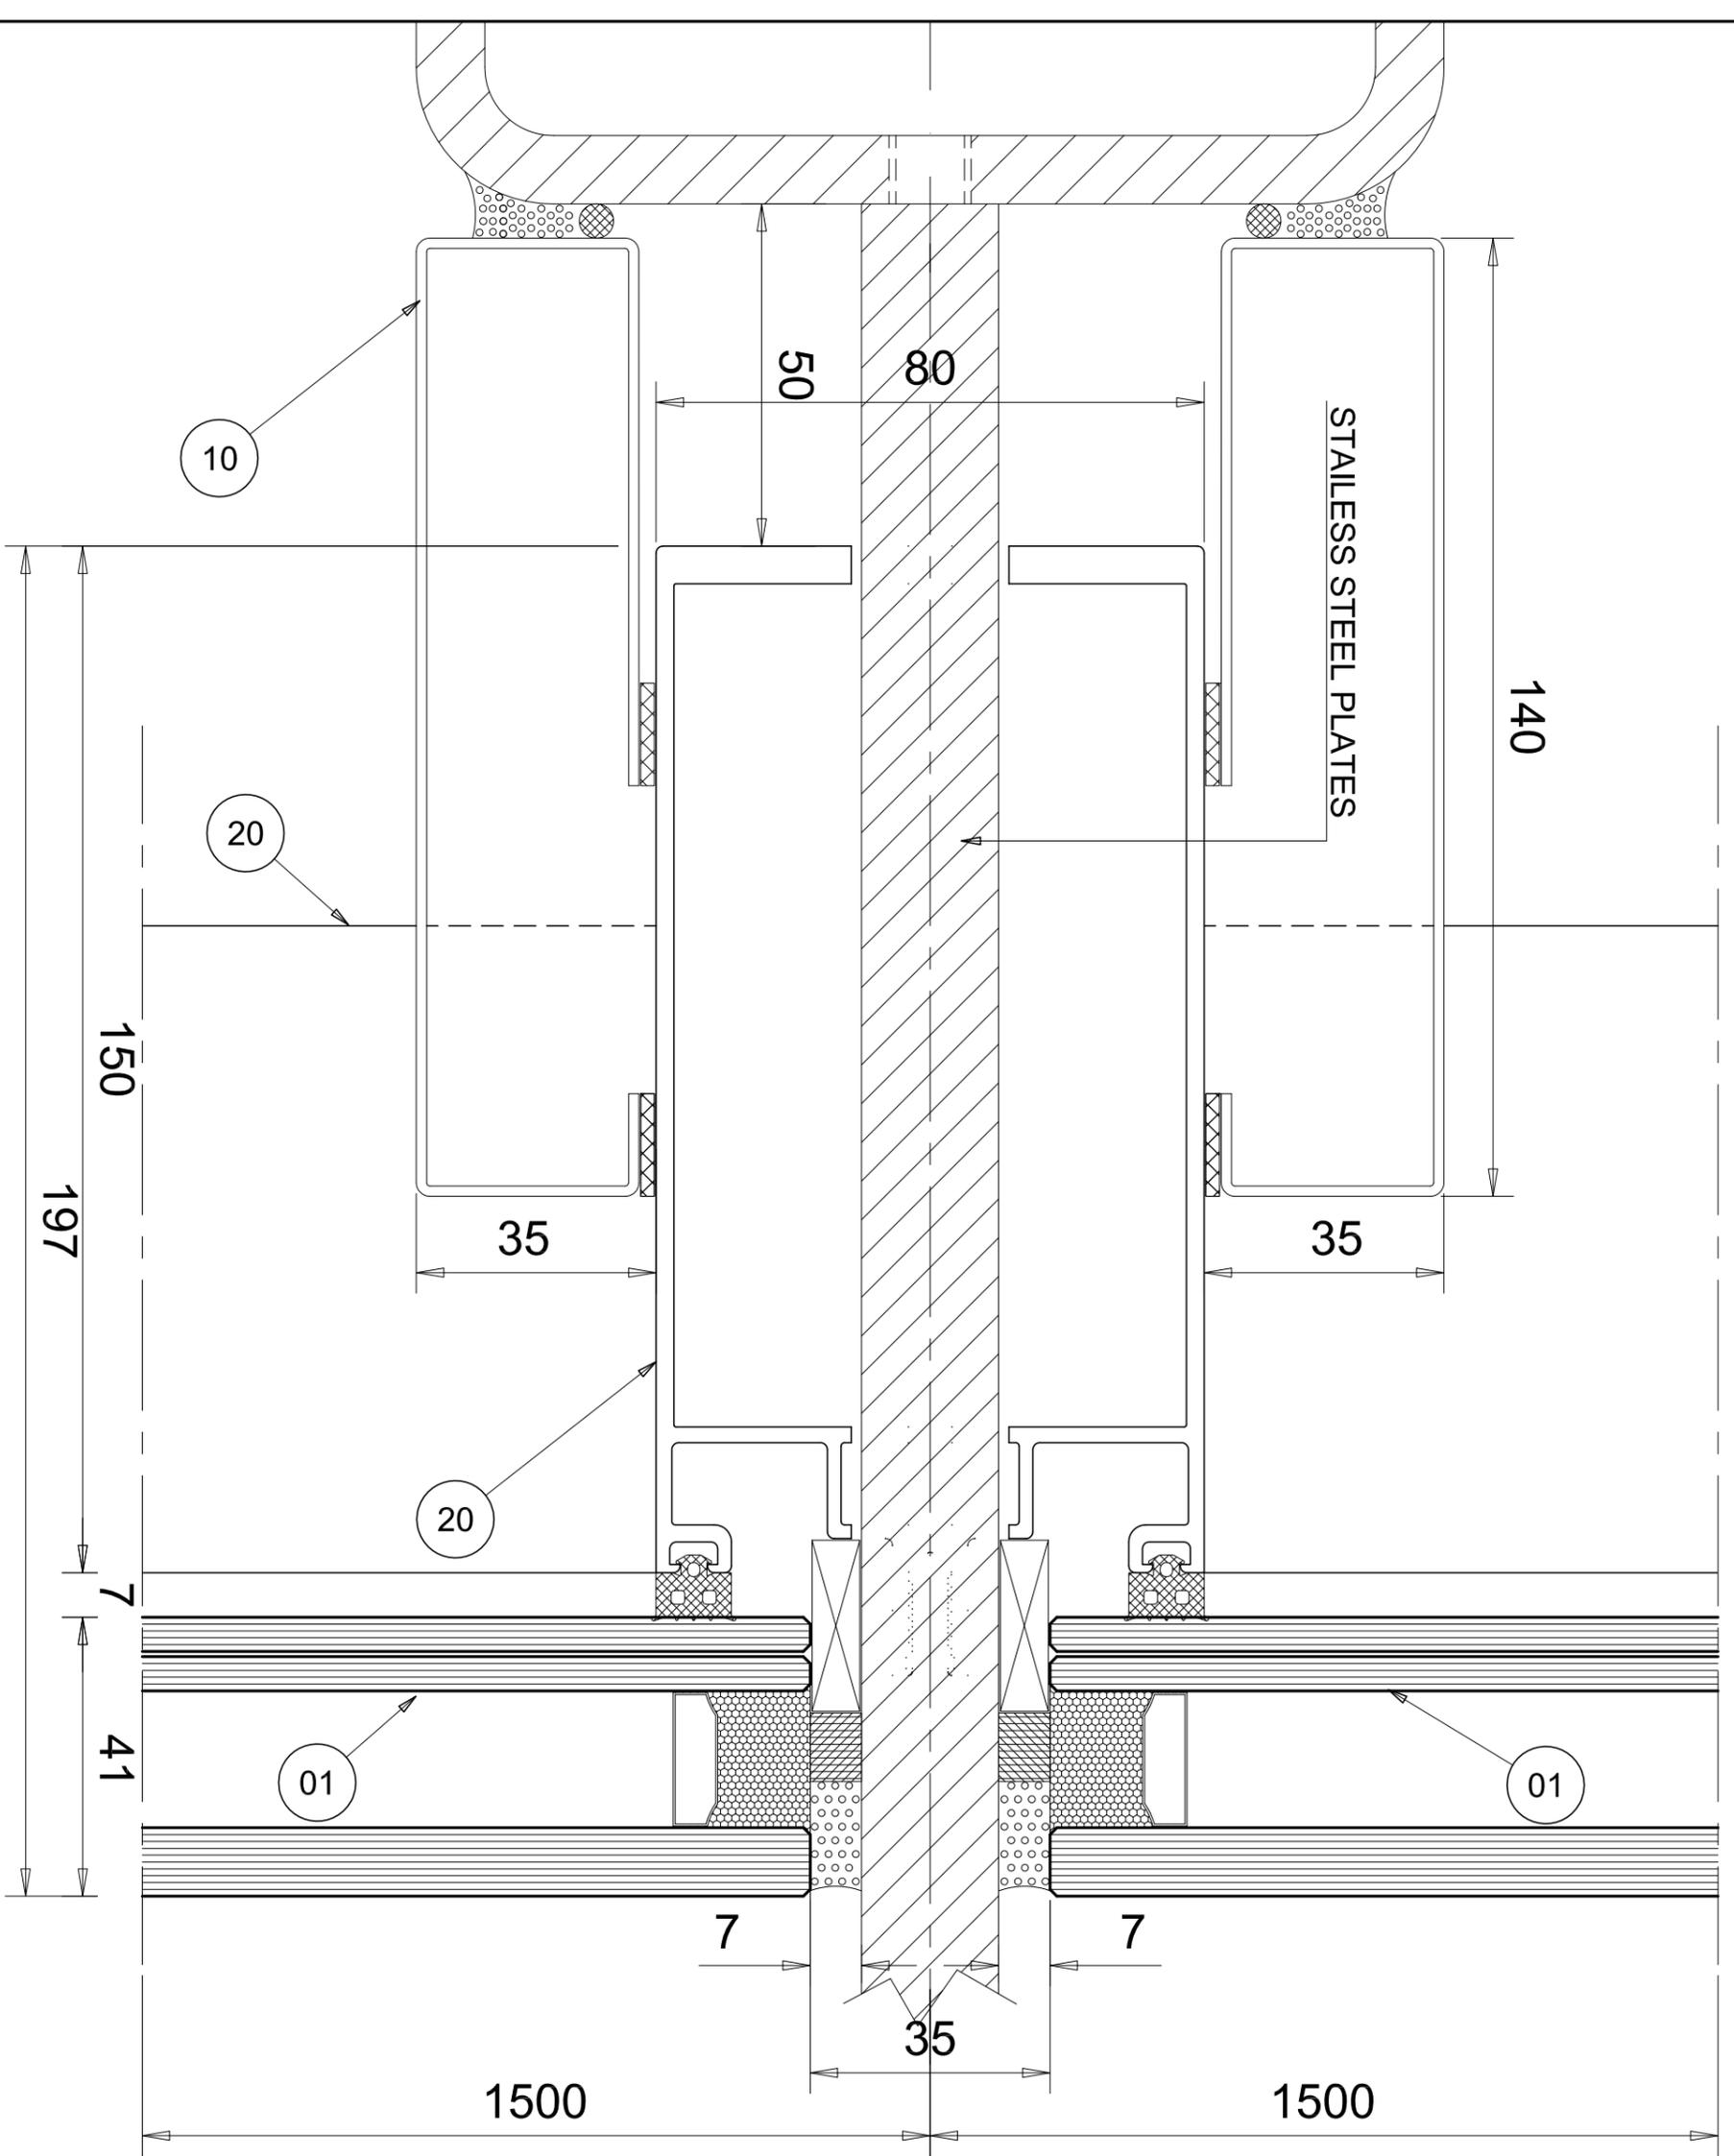

LEGEND	
No	MATERIAL
01	DOUBLE GLAZING UNIT OUTER LITE: 10mm, TOUGHENED HST INNER LITE: 5&2 CLEAR FLOAT ACOUSTIC PVB INTER LITE: 5&2 CLEAR FLOAT ACOUSTIC PVB TOUGHENED HST
02	SINGLE GLASS CLEAR FLOAT 10mm th TOUGHENED HST ENAMELLED COLOR BAL...
03	LAMINATED GLASS CLEAR FLOAT BR-4 TOUGHENED HST
10	ALUMINIUM SHEET 1&10 th
11	STAINLESS STEEL SHEET
12	GALVANIZED STEEL SHEET 1&10 th
13	GALVANIZED STEEL BRACKETS
20	ALUMINIUM EXTRUSIONS FOR C.W. PROFILES
30	STAINLESS STEEL SCREW
31	GALVANIZED STEEL SCREW
32	GALVANIZED STEEL BOLTS
33	EXPANSION BOLT
40	SILICONE DC 79& BLACK
41	EPDM EXTRUSION GASKET COLOR BLACK
42	SILICONE EXTRUSION GASKET COLOR BLACK
43	ROCK WOOL
44	1.5 mm thk ADHESIVE RUBBER MEMBRANE
45	RAISED FLOOR FINISH
46	CONCRETE SLAB
47	STEEL COLUMN
48	ALUMINIUM BORDER
49	STONE/CERAMIC FLOOR TILES
50	GYPSUM PLASTERBOARD FINISH
51	HALFEN SYSTEM SUPPORT
52	INTERNAL TEXTILE BLIND
53	ALUMINIUM SHEET 20/10 th

File : 926_Ae_07_107

Issue : Main Project

Scale : 1:1

j.n. 926/09

Detail: V-011


Rev.: -

Title :

The Curtain wall Glazing Facade - First floor roof
Skylight section detail

Page:

23

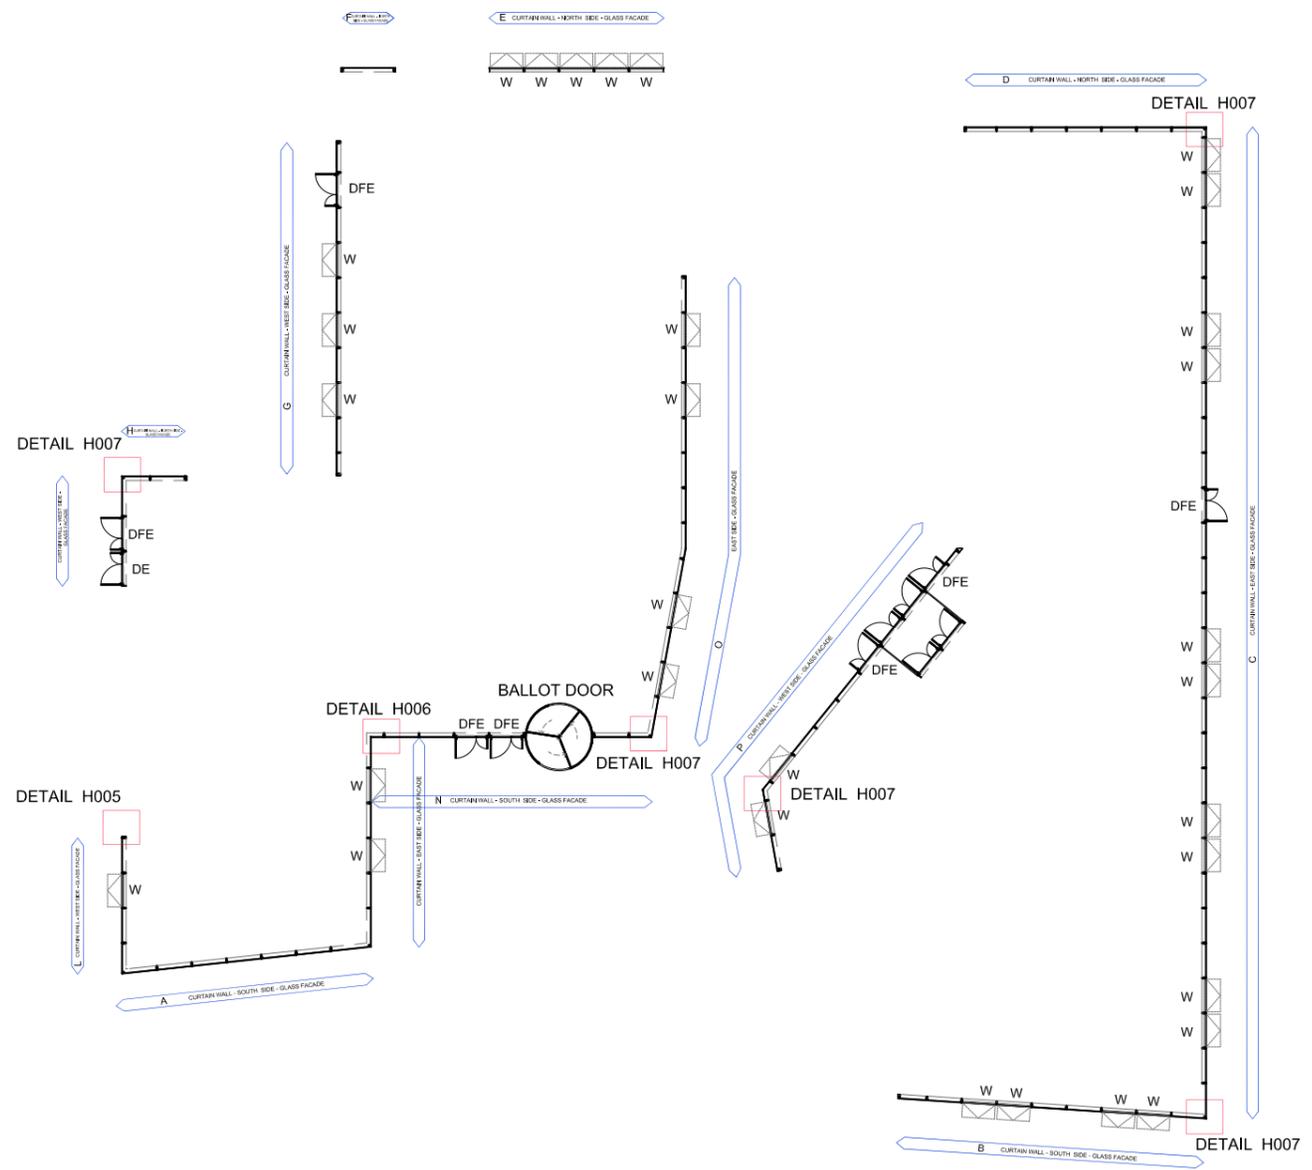

W = WINDOW

D = DOOR FOR MAINTENANCE

DFE = DOOR FIRE ESCAPE


- GLASS DOOR WITH INTERNAL STAINLESS STEEL PUSH BAR
- MICROSWITCH SEGNALATION
- CLOSURE REGULATOR (2 SHUTTERS)
- SELF CLOSING

DE = DOOR ENTRANCE

- GLASS AUTOMATIC DOOR
- MICROSWITCH SEGNALATION
- CLOSURE REGULATOR (2 SHUTTERS)
- SELF CLOSING

File : 926_Ae_07_107	Scale :	Issue :	Rev.:
	Main Project	926/09	-
Detail:			Plan_GF

The Curtain wall FACADES and Balustrade - Ground Floor
Plan of the Units Facades

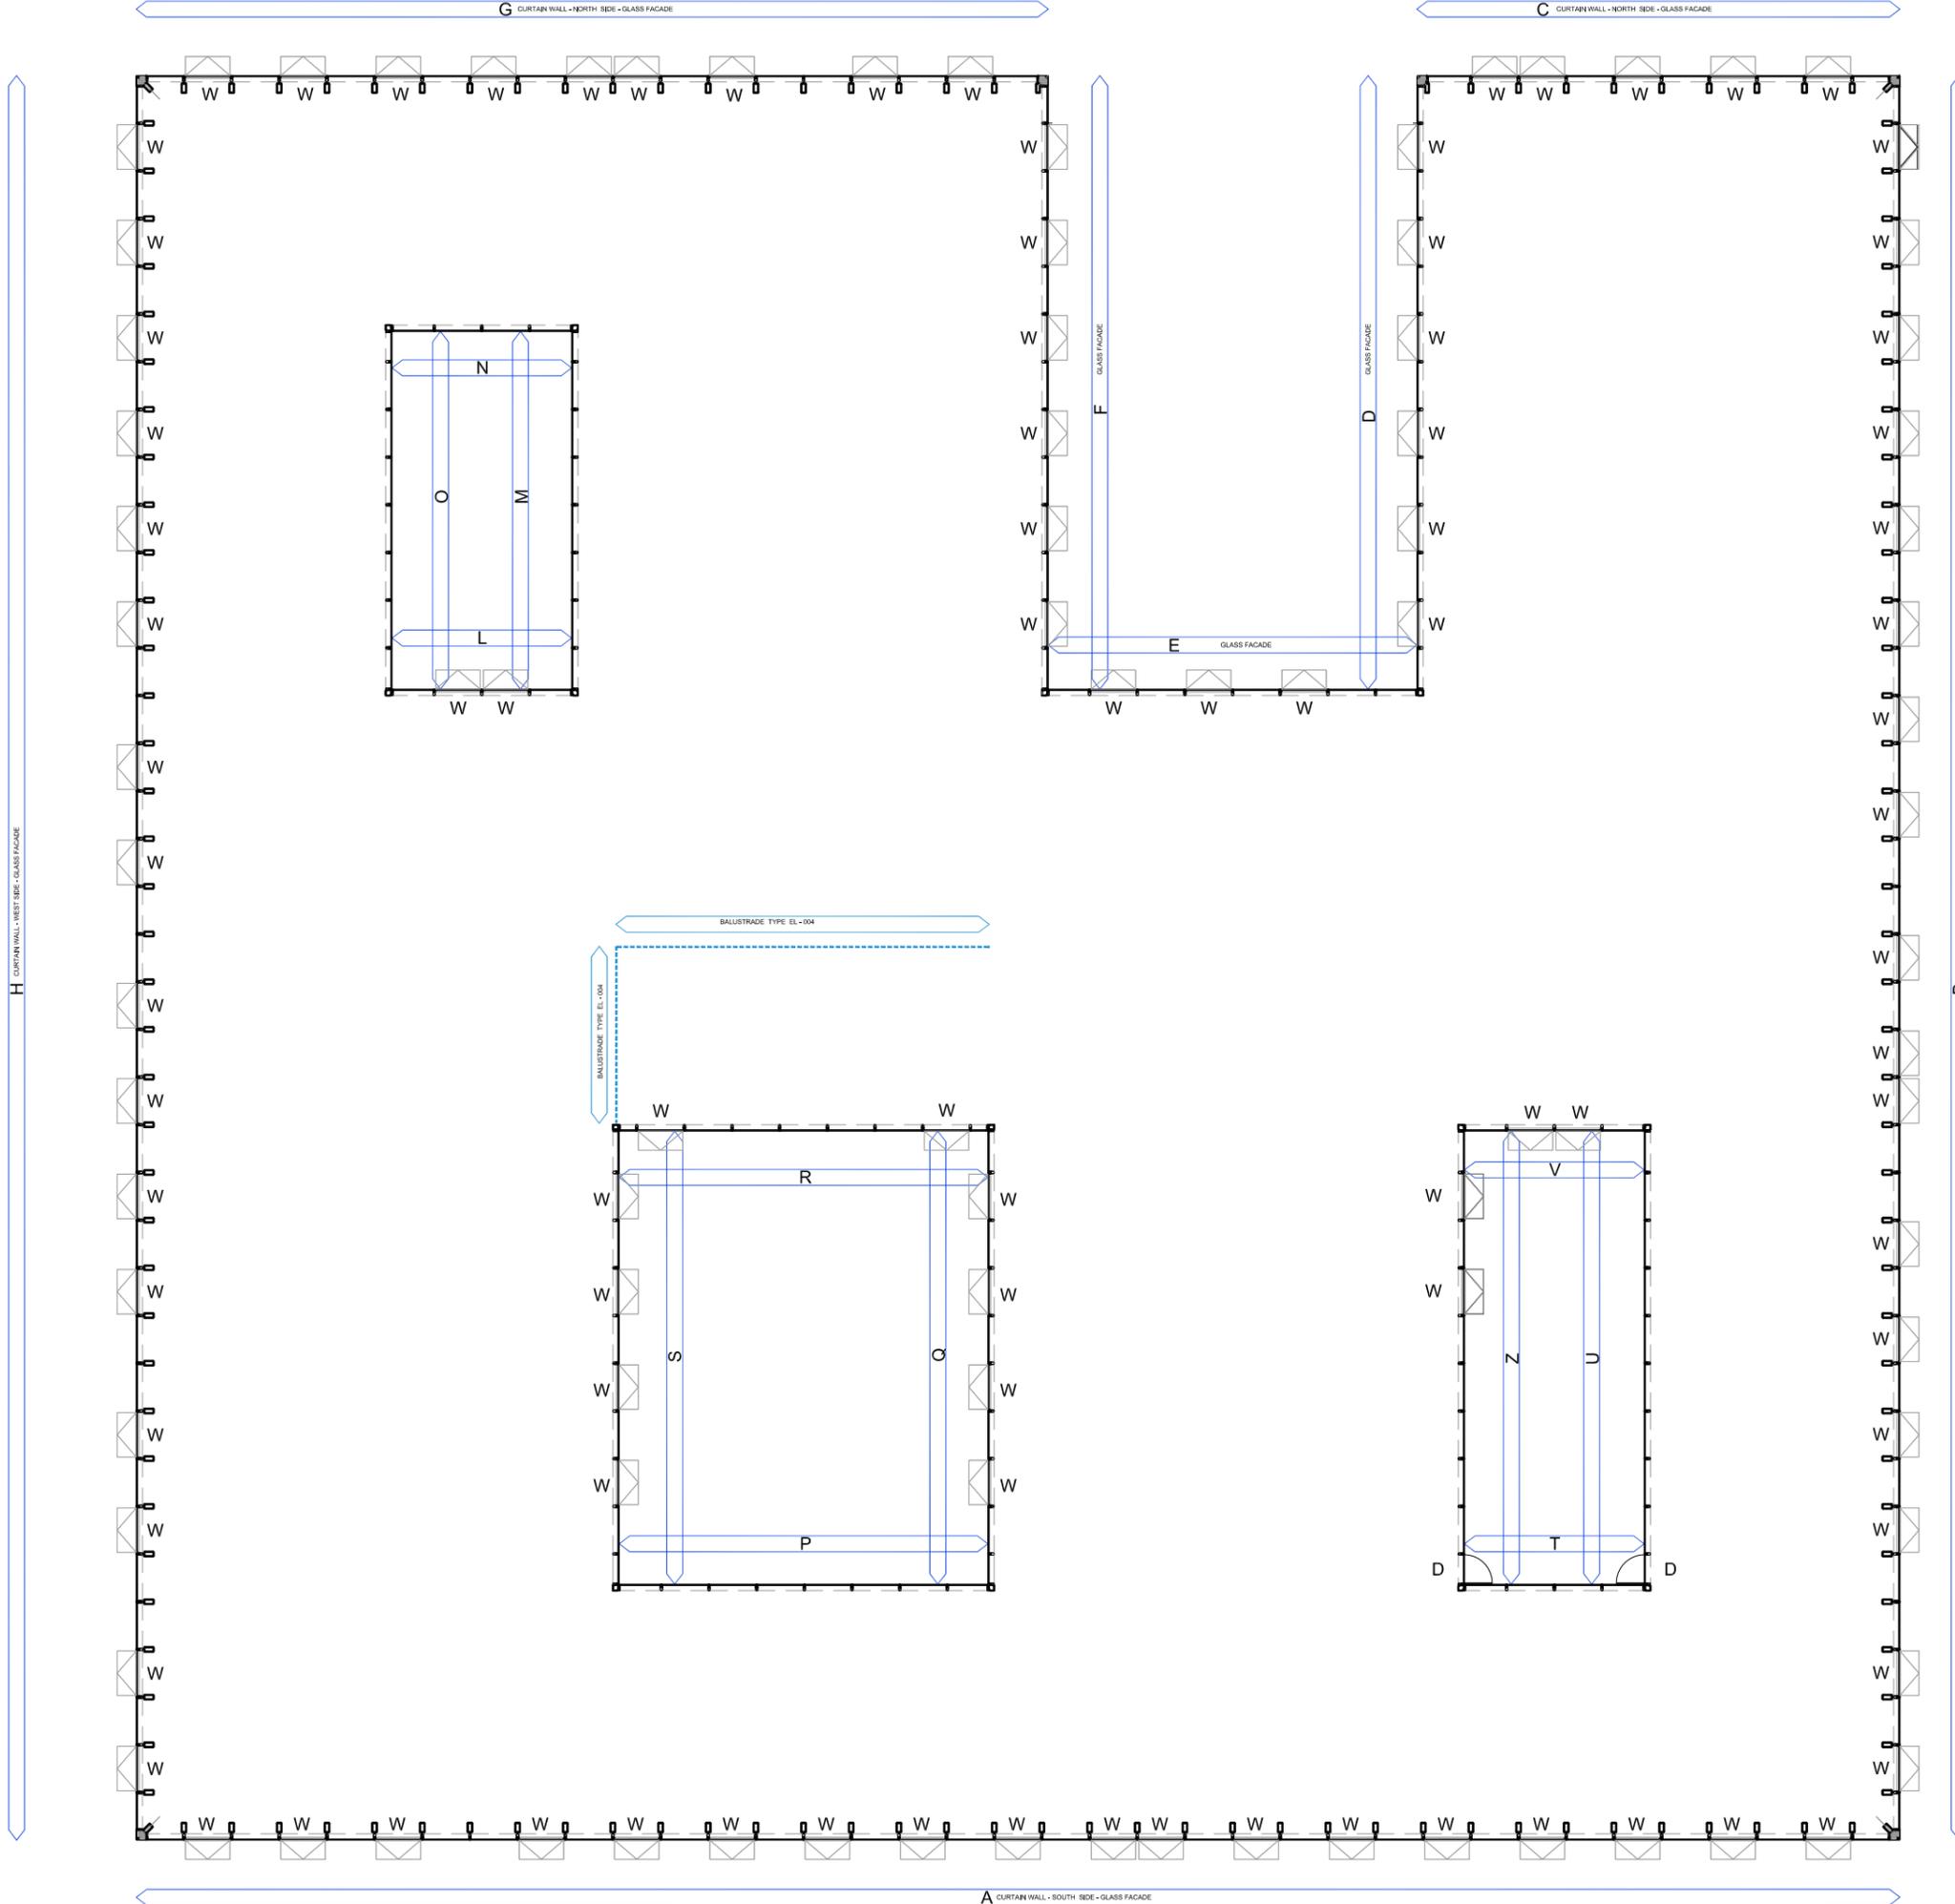


W = WINDOW


D = DOOR FOR MAINETANCE

File : 926_Ae_07_107	j.n.	926/09	Rev.:	-
Issue :	Main Project	-	Scale :	-
Detail:		Plan_FF		


The Curtain wall FACADES and Balustrade - First Floor
Plan of the Units Facades

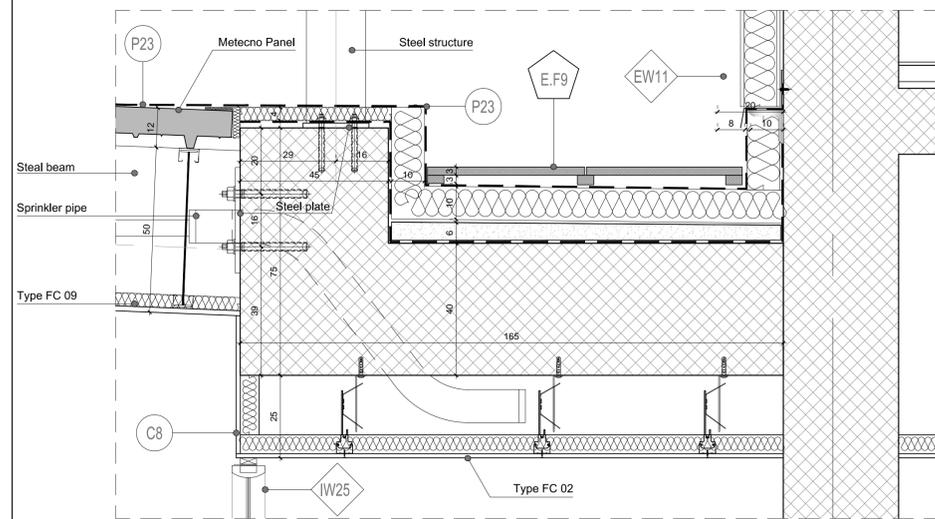


Detail no. 01
scale 1:10

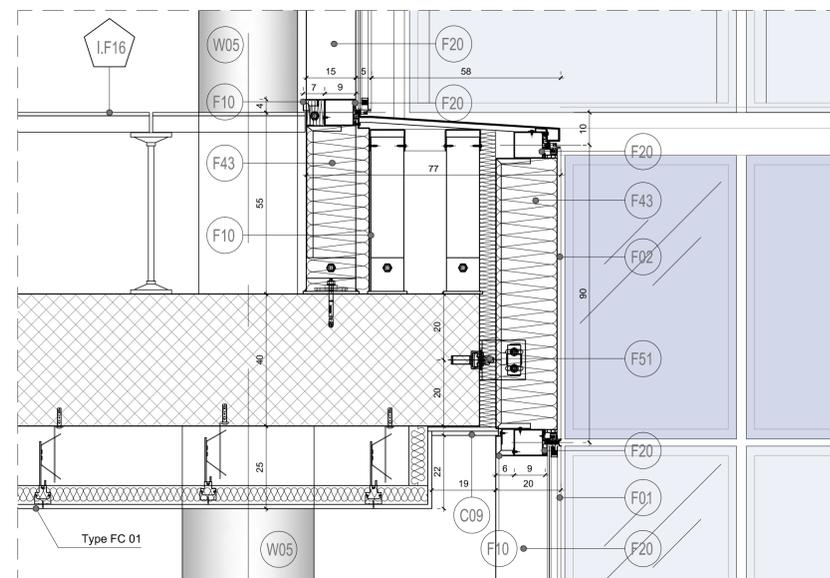


Detail no. 04
scale 1:10

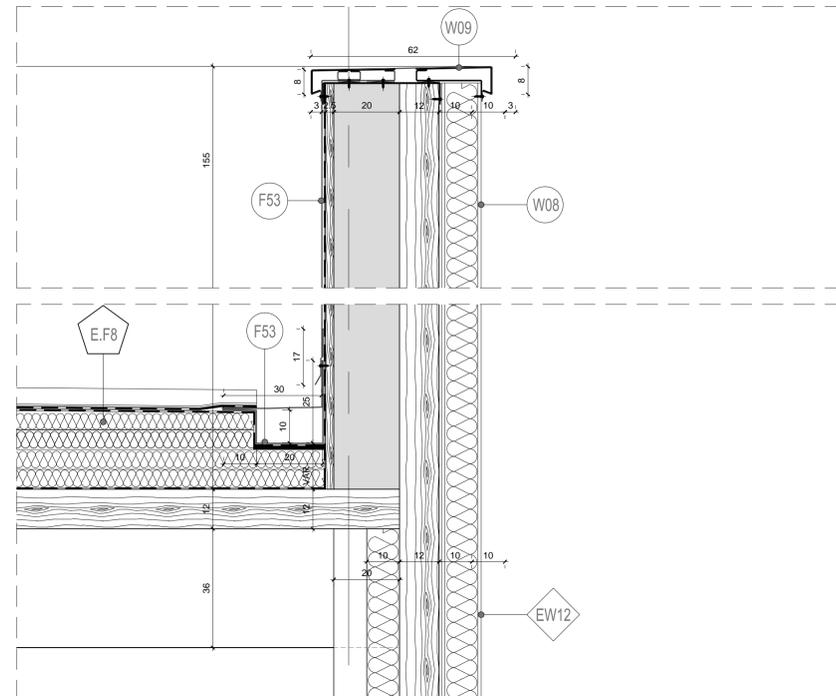


Detail no. 02
scale 1:10

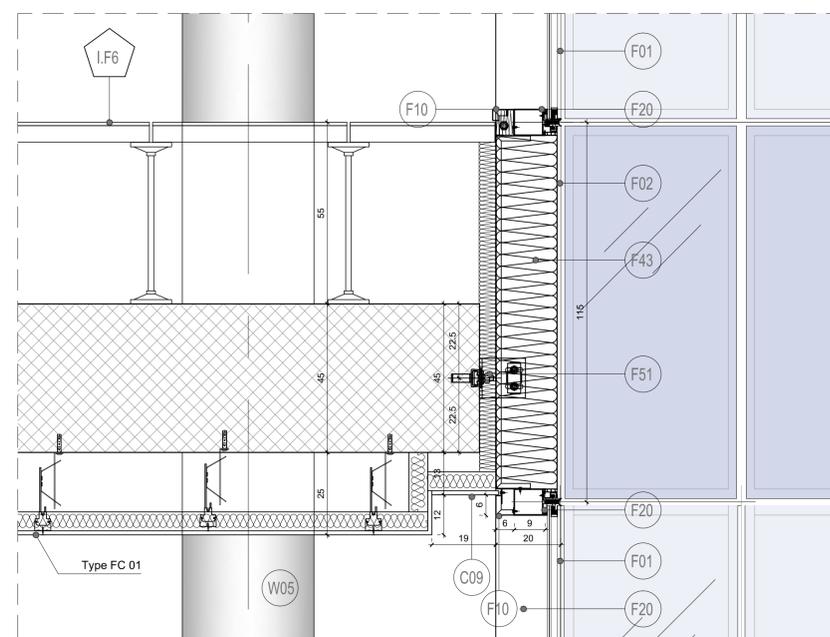

Detail no. 05
scale 1:10

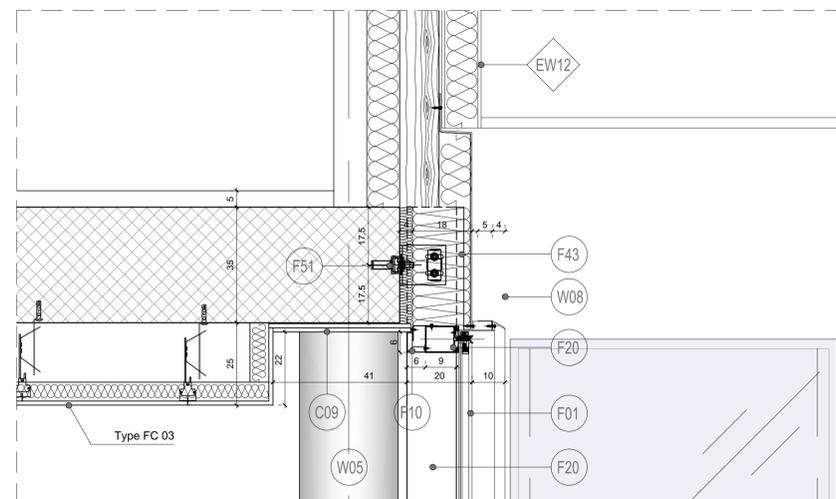

Detail no. 03
scale 1:10

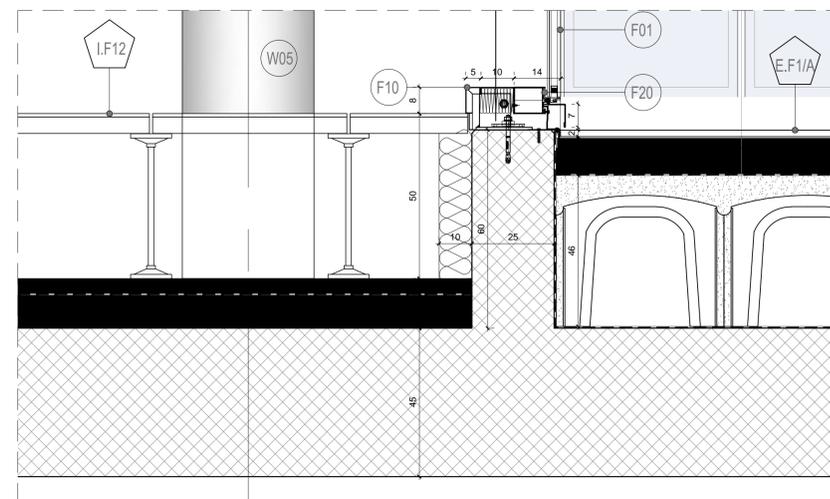

Detail no. 06
scale 1:10


CONCERNING:

- FLOOR TYPES AND MATERIALS
SEE DRAWINGS n. 926_Ae_02_101 + 106
- FALSE CEILING TYPES
SEE DRAWINGS n. 926_Ae_03_101 + 105
- WALL PARTITION TYPES
SEE DRAWINGS n. 926_Ae_04_101 + 106
- THE CURTAIN WALL TYPES
SEE DRAWINGS n. 926_Ae_07_101 + 107

THE PRESENT DETAIL SECTION REFER TO SPECIFIC TYPES OF:

- P (PAVEMENT) OF EACH FLOORS
- C (FALSE CEILING) OF EACH LEVEL
- W (WALL PARTITION) OF EACH FLOOR
- F (FACADES) OF EACH FLOORS AND SPECIFIC OF THE FINISHING.

THE CODES OF THE MATERIALS FINISHING ARE REFERED TO THE RELATED LEGEN OF PAVEMENT (SEE FLOORS TYPES DRAWINGS), FALSE CEILING (SEE CEILING TYPES DRAWINGS), WALL PARTITION S (SEE WALLS TYPES DRAWINGS) AND FACADES DETAILS (SEE THE CURTAIN WALL TYPES DRAWINGS).

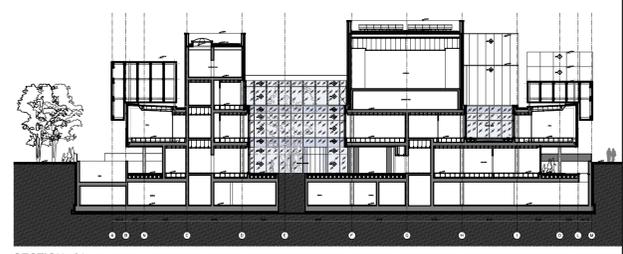

SECTION n°4

LEGEND	
No	FACADE MATERIAL
F 01	DOUBLE GLAZING UNIT OUTER LITE: 10mm, TOUGHENED HST SPACE 20mm, ARGON 90% WE INNER LITE: 55,2 CLEAR FLOAT ACOUSTIC PVB
F 02	SINGLE GLASS CLEAR FLOAT 10mm th TOUGHENED HST ENAMELLED COLOR RAL...
F 10	ALUMINIUM SHEET 15/10 th
F 20	ALUMINIUM EXTRUSIONS FOR C.W. PROFILES
F 43	ROCK WOOL
F 51	HALFEN SYSTEM SUPPORT
F 53	ALUMINIUM SHEET 20/10 th
No	FLOOR MATERIAL
P 21	EXTERNAL PAVING FINISHING TYPE DORATA EXTE CHISELLED OF PORCELAINGRES OR SIMILAR, 600X600 MM
P 23	DOUBLE BITUMINOUS WATERPROOF
P 25	WATER
P 26	STEEL BEAM
No	CEILING MATERIAL
C 08	GYPSUM PANEL TH.12,5 mm PREGYFLAM BA13 FROM LAFARGE PLASTER BOARD TYPE CLASSE A1 UNI_EN_13501
C 09	TWO GYPSUM PANEL TH.12,5 mm PREGYFLAM BA13 FROM LAFARGE PLASTER BOARD TYPE CLASSE A1 UNI_EN_13501
No	WALL MATERIAL
W 05	CONCRETE PILAR
W 08	SANDWICH PANEL WOOL INSULATION
W 09	ALUMINIUM 20/10 TH MM RAL GOLD

INVESTITOR: JOINT PROJECT ON ENVIRONMENT AND ENERGY BETWEEN ITALY AND MONTENEGRO
 MINISTRY OF THE ENVIRONMENT, LAND AND SEA OF THE REPUBLIC OF ITALY
 MINISTARSTVO TURIZMA I ZAŠTITE ŽIVOTNE SREDEINE

PROJECT MANAGEMENT AND STRUCTURAL DESIGN: FCM Favorobitnik inženjering
 30035 Mirano Venezia - Italia
 Tel. +39 041 5785711 Fax +39 041 4325931
 www.favorobitnik.com montenegro@favorobitnik.com

MEP DESIGN: Manetis-Tifs
 Corso Stati Uniti 56 - 35127 Padova, Italia
 Tel. +39 049 8707110 Fax +39 049 8985201
 www.manetis-tifs.it tpm@manetis-tifs.it e-mail: info@manetis-tifs.it

ARCHITECTURAL CONCEPT DESIGN: MC A
 Via Da Carracci, 6/M - 40129 Bologna, Italia
 Tel. +39 051 63 13 381 Fax +39 051 63 13 316
 e-mail: mc@mcarchitetti.it

LOCAL SUPPORT: DFS Engineering
 Montenegro
 tel. +382 20 228 501 e-mail: info@dfs-engineering.com

Local Projektant: studio SYNTHESIS architecture & design
 Bul. Džordža Vasiljevića bb 81000 Podgorica, Crna Gora
 t: +382 20 228 083 f: +382 20 228 082
 e-mail: mc@mcarchitetti.it

Projektant faze - KONSTRUKCIJA: FRAME Project d.o.o.
 Projekatna za projektovanje i izradu projekata
 Projekatant faze - VODOVOD I KANALIZACIJA: HIDROFOKUS
 Projekatant faze - ELEKTROINSTALACIJE / JAKA STRUJA: SIEMENSYS
 Projekatant faze - ELEKTROINSTALACIJE / SLABA STRUJA: SIMES
 Projekatant faze - ZAŠTITA OD POŽARA: NOVA ENERGIJA
 Projekatant faze - ZAŠTITA OD POŽARA: PREVOZING d.o.o.


Objekat i mjesto: Poslovni objekat - objekat Vlade Crne Gore
 ENERGETSKI EFIKASNA ZGRADA
 Urbanistička parcela 9
 DUP "Univerzitetski centar" - izmjene i dopune
 Podgorica, Crna Gora

ISSUE: MAIN DESIGN ARCHITECTURAL PROJECT
 TITLE: Detail 01-02-03-04-05-06


REV.	DATE	FILE	SUBJECT	DRAW	APPR.
a					
b					
c					
d					

ISSUE NR. Ae_08_103


DATE	SCALE	FILE
30/11/2010	1:10	926_Ae_08_103-104.dwg
J.N. 926	DRAW A.B.	APPROVED: S.F.

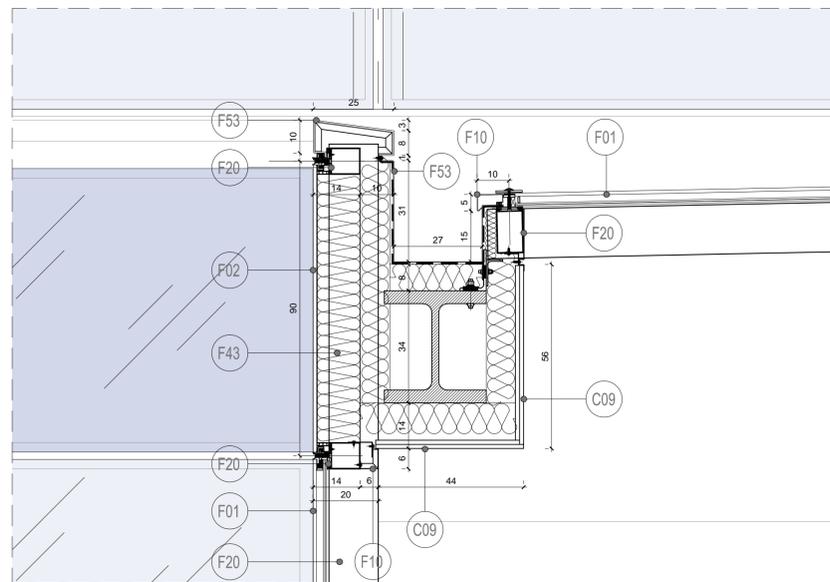


Detail no. 13
scale 1:10

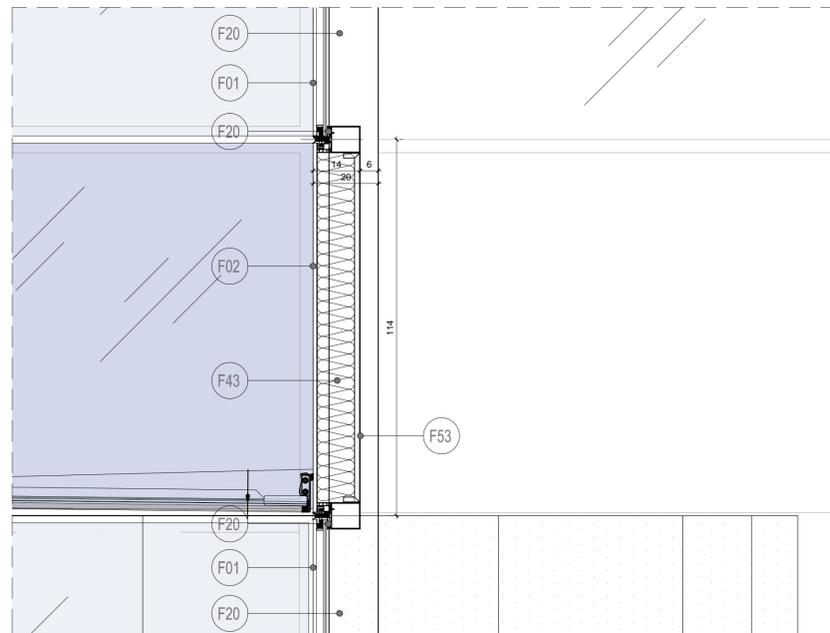


Detail no. 14
scale 1:10

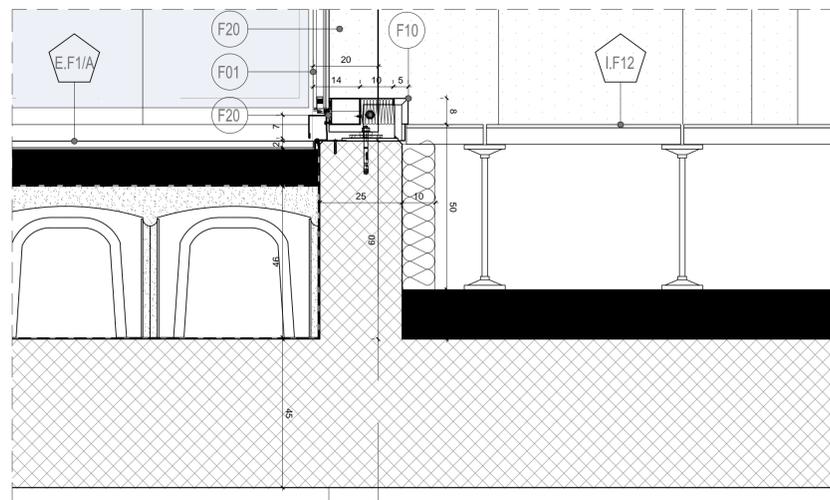


Detail no. 15
scale 1:10

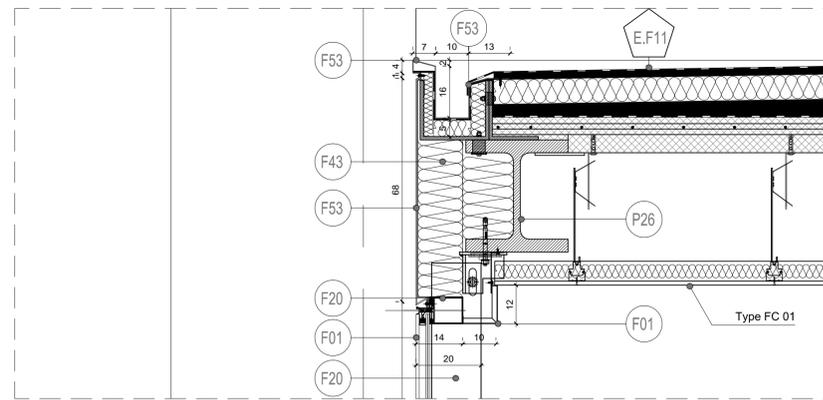


Detail no. 16
scale 1:10

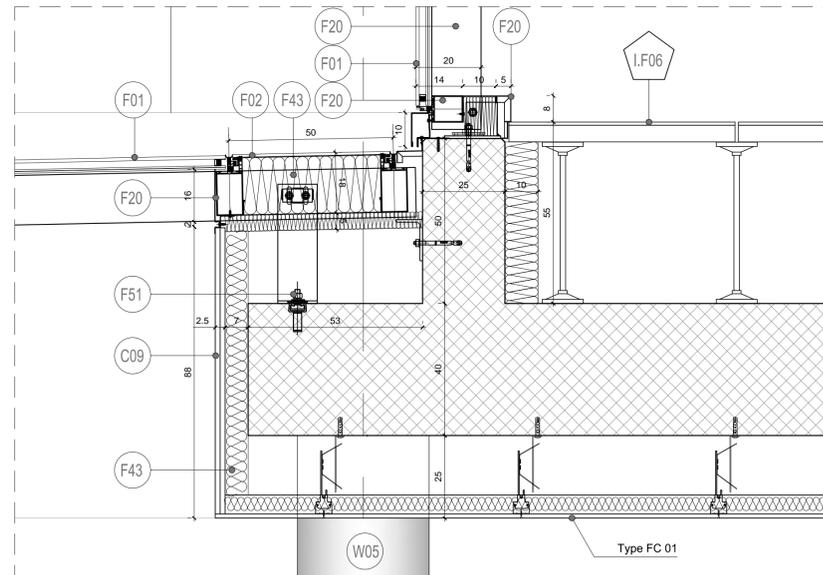

Detail no. 17
scale 1:10

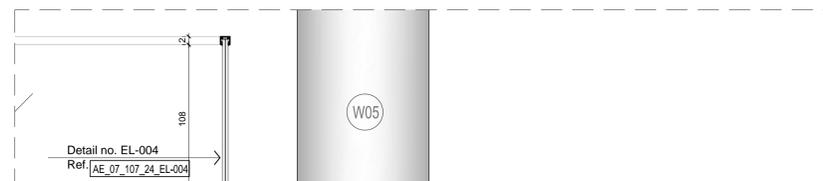

Detail no. EL-004
Ref. AE_07_107_24_EL-004

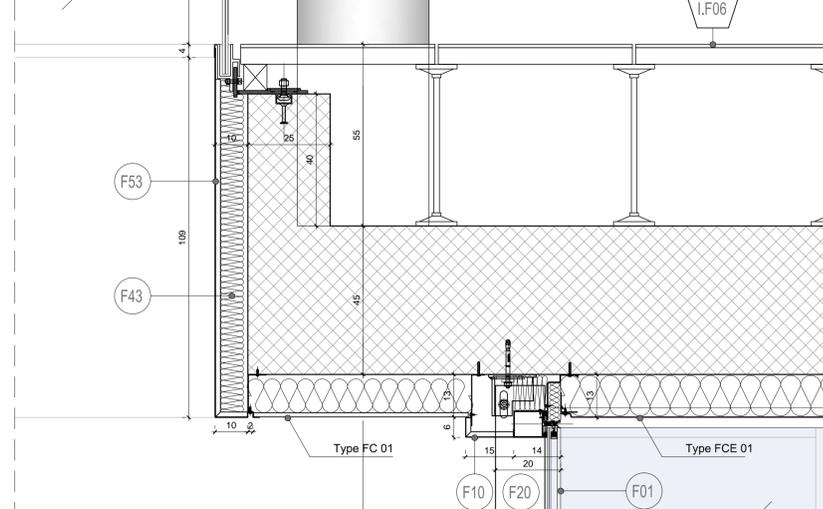

Detail no. 18
scale 1:10

CONCERNING:


- FLOOR TYPES AND MATERIALS
SEE DRAWINGS n. 926_Ae_02_101 + 106
- FALSE CEILING TYPES
SEE DRAWINGS n. 926_Ae_03_101 + 105
- WALL PARTITION TYPES
SEE DRAWINGS n. 926_Ae_04_101 + 106
- THE CURTAIN WALL TYPES
SEE DRAWINGS n. 926_Ae_07_101 + 107

THE PRESENT DETAIL SECTION REFER TO SPECIFIC TYPES OF:

- P (PAVEMENT) OF EACH FLOORS
- C (FALSE CEILING) OF EACH LEVEL
- W (WALL PARTITION) OF EACH FLOOR
- F (FACADES) OF EACH FLOORS

AND SPECIFIC OF THE FINISHING.

THE CODES OF THE MATERIALS FINISHING ARE REFERED TO THE RELATED LEGEND OF PAVMENT (SEE FLOORS TYPES DRAWINGS), FALSE CEILING (SEE CEILING TYPES DRAWINGS), WALL PARTITION S (SEE WALLS TYPES DRAWINGS) AND FACADES DETAILS (SEE THE CURTAIN WALLS TYPES DRAWINGS).

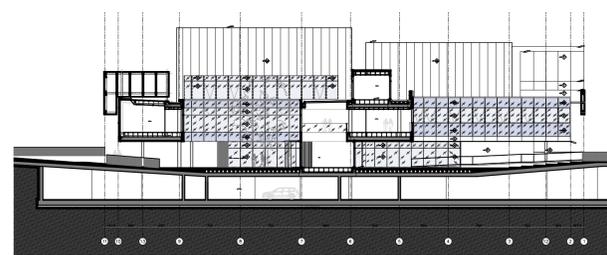

SECTION n°5

LEGEND	
Nº	FACADE MATERIAL
F 01	DOUBLE GLAZING UNIT OUTER LITE: 10mm, TOUGHENED HST SPACE 20mm, ARGON 90% WE INNER LITE: 55,2 CLEAR FLOAT ACOUSTIC PVB
F 02	SINGLE GLASS CLEAR FLOAT 10mm th TOUGHENED HST ENAMELLED COLOR RAL...
F 10	ALUMINIUM SHEET 15/10 th
F 20	ALUMINIUM EXTRUSIONS FOR C.W. PROFILES
F 43	ROCK WOOL
F 51	HALFEN SYSTEM SUPPORT
F 53	ALUMINIUM SHEET 20/10 th
Nº	FLOOR MATERIAL
P 21	EXTERNAL PAVING FINISHING TYPE DORATA EXTE CHISELLED OF PORCELAINGRES OR SIMILAR, 600X600 MM
P 23	DOUBLE BITUMINOUS WATERPROOF
P 25	WATER
P 26	STEEL BEAM
Nº	CEILING MATERIAL
C 08	GYPSUM PANEL TH.12,5 mm PREGYFLAM BA13 FROM LAFARGE PLASTER BOARD TYPE CLASSE A1 UNI_EN_13501
C 09	TWO GYPSUM PANEL TH.12,5 mm PREGYFLAM BA13 FROM LAFARGE PLASTER BOARD TYPE CLASSE A1 UNI_EN_13501
Nº	WALL MATERIAL
W 05	CONCRETE PILAR
W 08	SANDWICH PANEL WOOL INSULATION
W 09	ALUMINIUM 20/10 TH MM RAL GOLD

INVESTITOR: JOINT PROJECT ON ENVIRONMENT AND ENERGY BETWEEN ITALY AND MONTENEGRO
 MINISTARSTVO TURIZMA I ZAŠTITE ŽIVOTNE SREDEINE
 MINISTARSTVO TURIZMA I ZAŠTITE ŽIVOTNE SREDEINE

Bul. Džorđa Vukotina bb
81000 Podgorica, Crna Gora

Bul. Džorđa Vukotina bb
81000 Podgorica, Crna Gora

PROJECT MANAGEMENT AND STRUCTURAL DESIGN:
FCM FaveroMilan ingegneria

MEP DESIGN:
Manetis-Tifs

ARCHITECTURAL CONCEPT DESIGN:
MC A

LOCAL SUPPORT:
DFS DFS Engineering

Local Projektant:
studio SYNTHESIS architecture & design

Projektant faze - KONSTRUKCIJA:
FRAME Project d.o.o.

Projektant faze - VODOVOD I KANALIZACIJA:
HIDROFOKUS

Projektant faze - ELEKTROINSTALACIJE / JUKA STRUJN:
SIEMENSIS

Projektant faze - ELEKTROINSTALACIJE / JUKA STRUJN:
SIMES

Projektant faze - MAŠINSKE INSTALACIJE:
NOVA ENERGIJA

Projektant faze - ZAŠTITA OD POŽARA:
PREVIZIJE

Objekat i izmjena:
**Poslovni objekat - objekat Vlade Crne Gore
 ENERGETSKI EFIKASNA ZGRADA
 Urbanistička parcela 9
 DUP "Univerzitetski centar" - izmjene i dopune
 Podgorica, Crna Gora**

ISSUE
MAIN DESIGN ARCHITECTURAL PROJECT

TITLE
 Detail 13-14-15-16-17-18

REV.	DATE	FILE	SUBJECT	DRAW	APPR.
a					
b					
c					
d					

ISSUE NR:
Ae_08_105

DATE	SCALE	FILE
30/11/2010	1:10	926_Ae_08_105-106.dwg

J.N.	DRAW	APPROVED
926	A.B.	S.F.

